




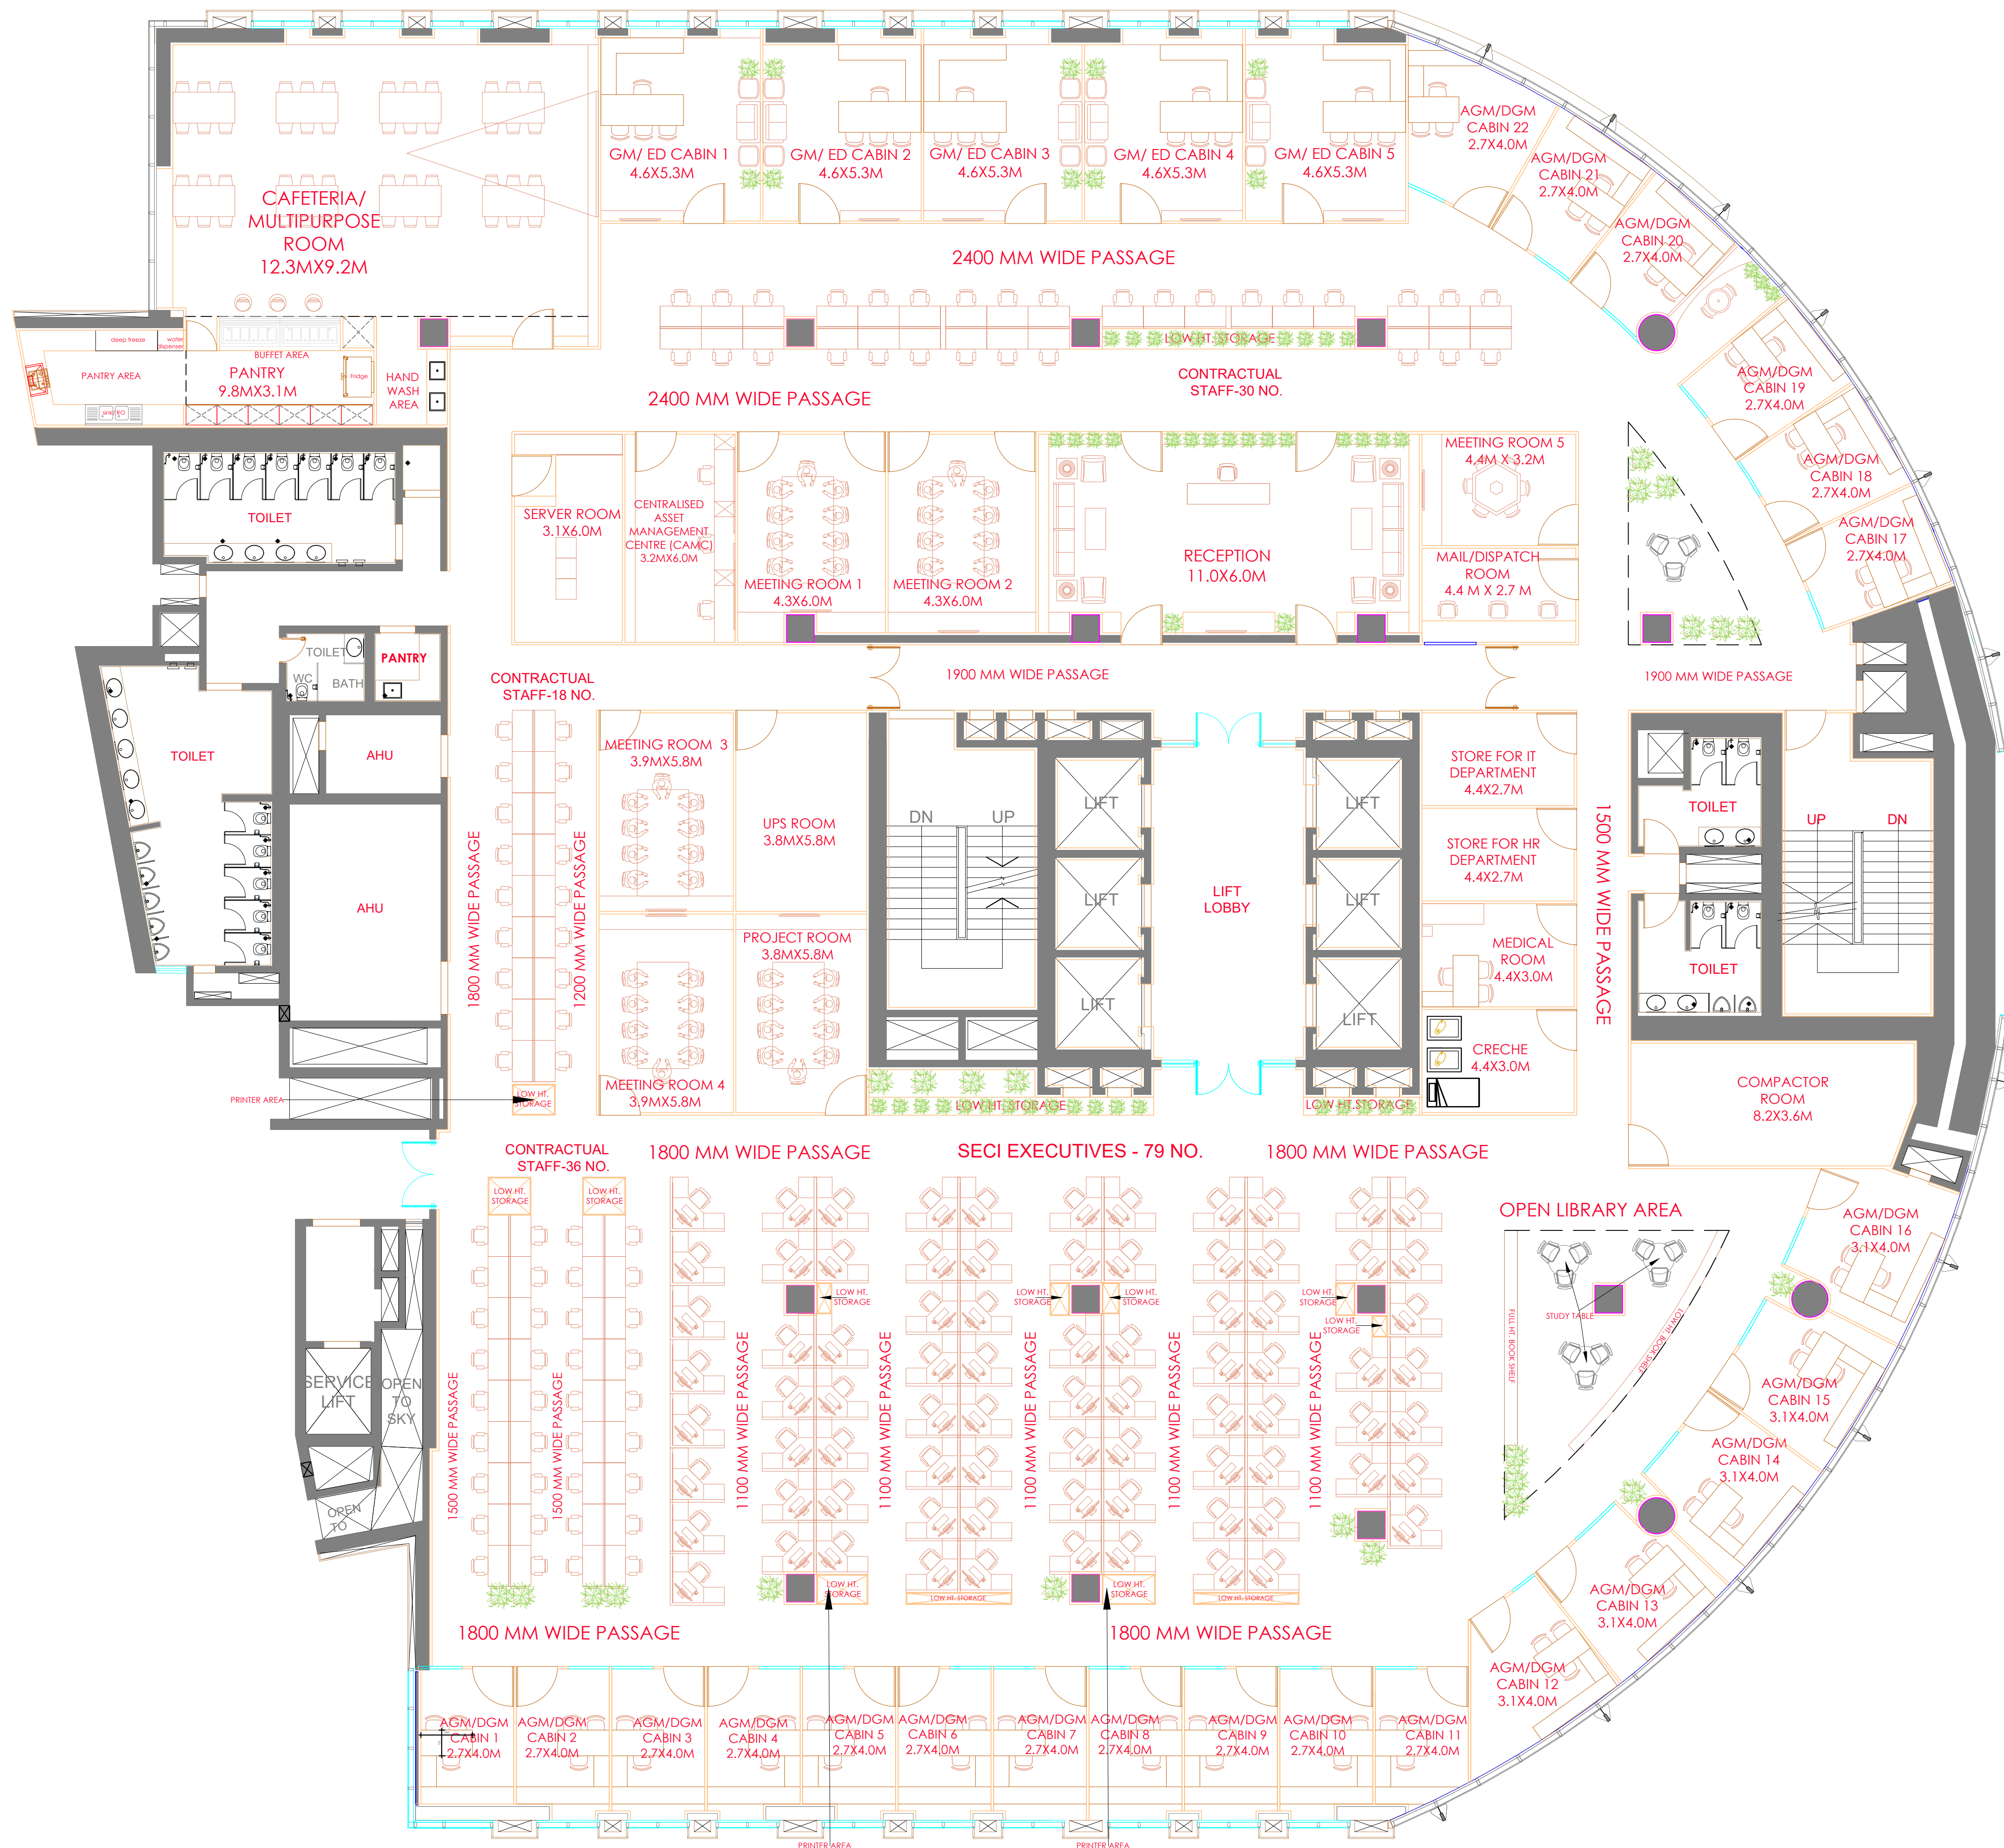


TENDER DRAWING

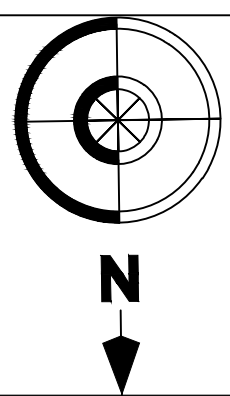

CLIENT:	PROJECT:	ARCHITECT:	DRAWING TITLE:	DATE :	SCALE :	SHEET
SOLAR ENERGY CORPORATION OF INDIA (SECI)	ARCHITECTURAL AND ENGINEERING CONSULTANCY SERVICES FOR INTERIOR WORKS AT TOWER-F 2nd & 3rd FLOOR ,NAUROJI NAGAR, NBCC DELHI	ATKV CONSULTANTS PVT. LTD. E-107 (LOWER GROUND FLOOR) G.K.-II NEW DELHI-110048 PH.NO. 40536580,29214906 TEL. FAX: 29214906	SECOND FLOOR INTERIOR LAYOUT	24-02-2025	NTS	A1
			DRAWN BY : AKANKSHA	DRAWING NO: SECI-INT-SF(01)		


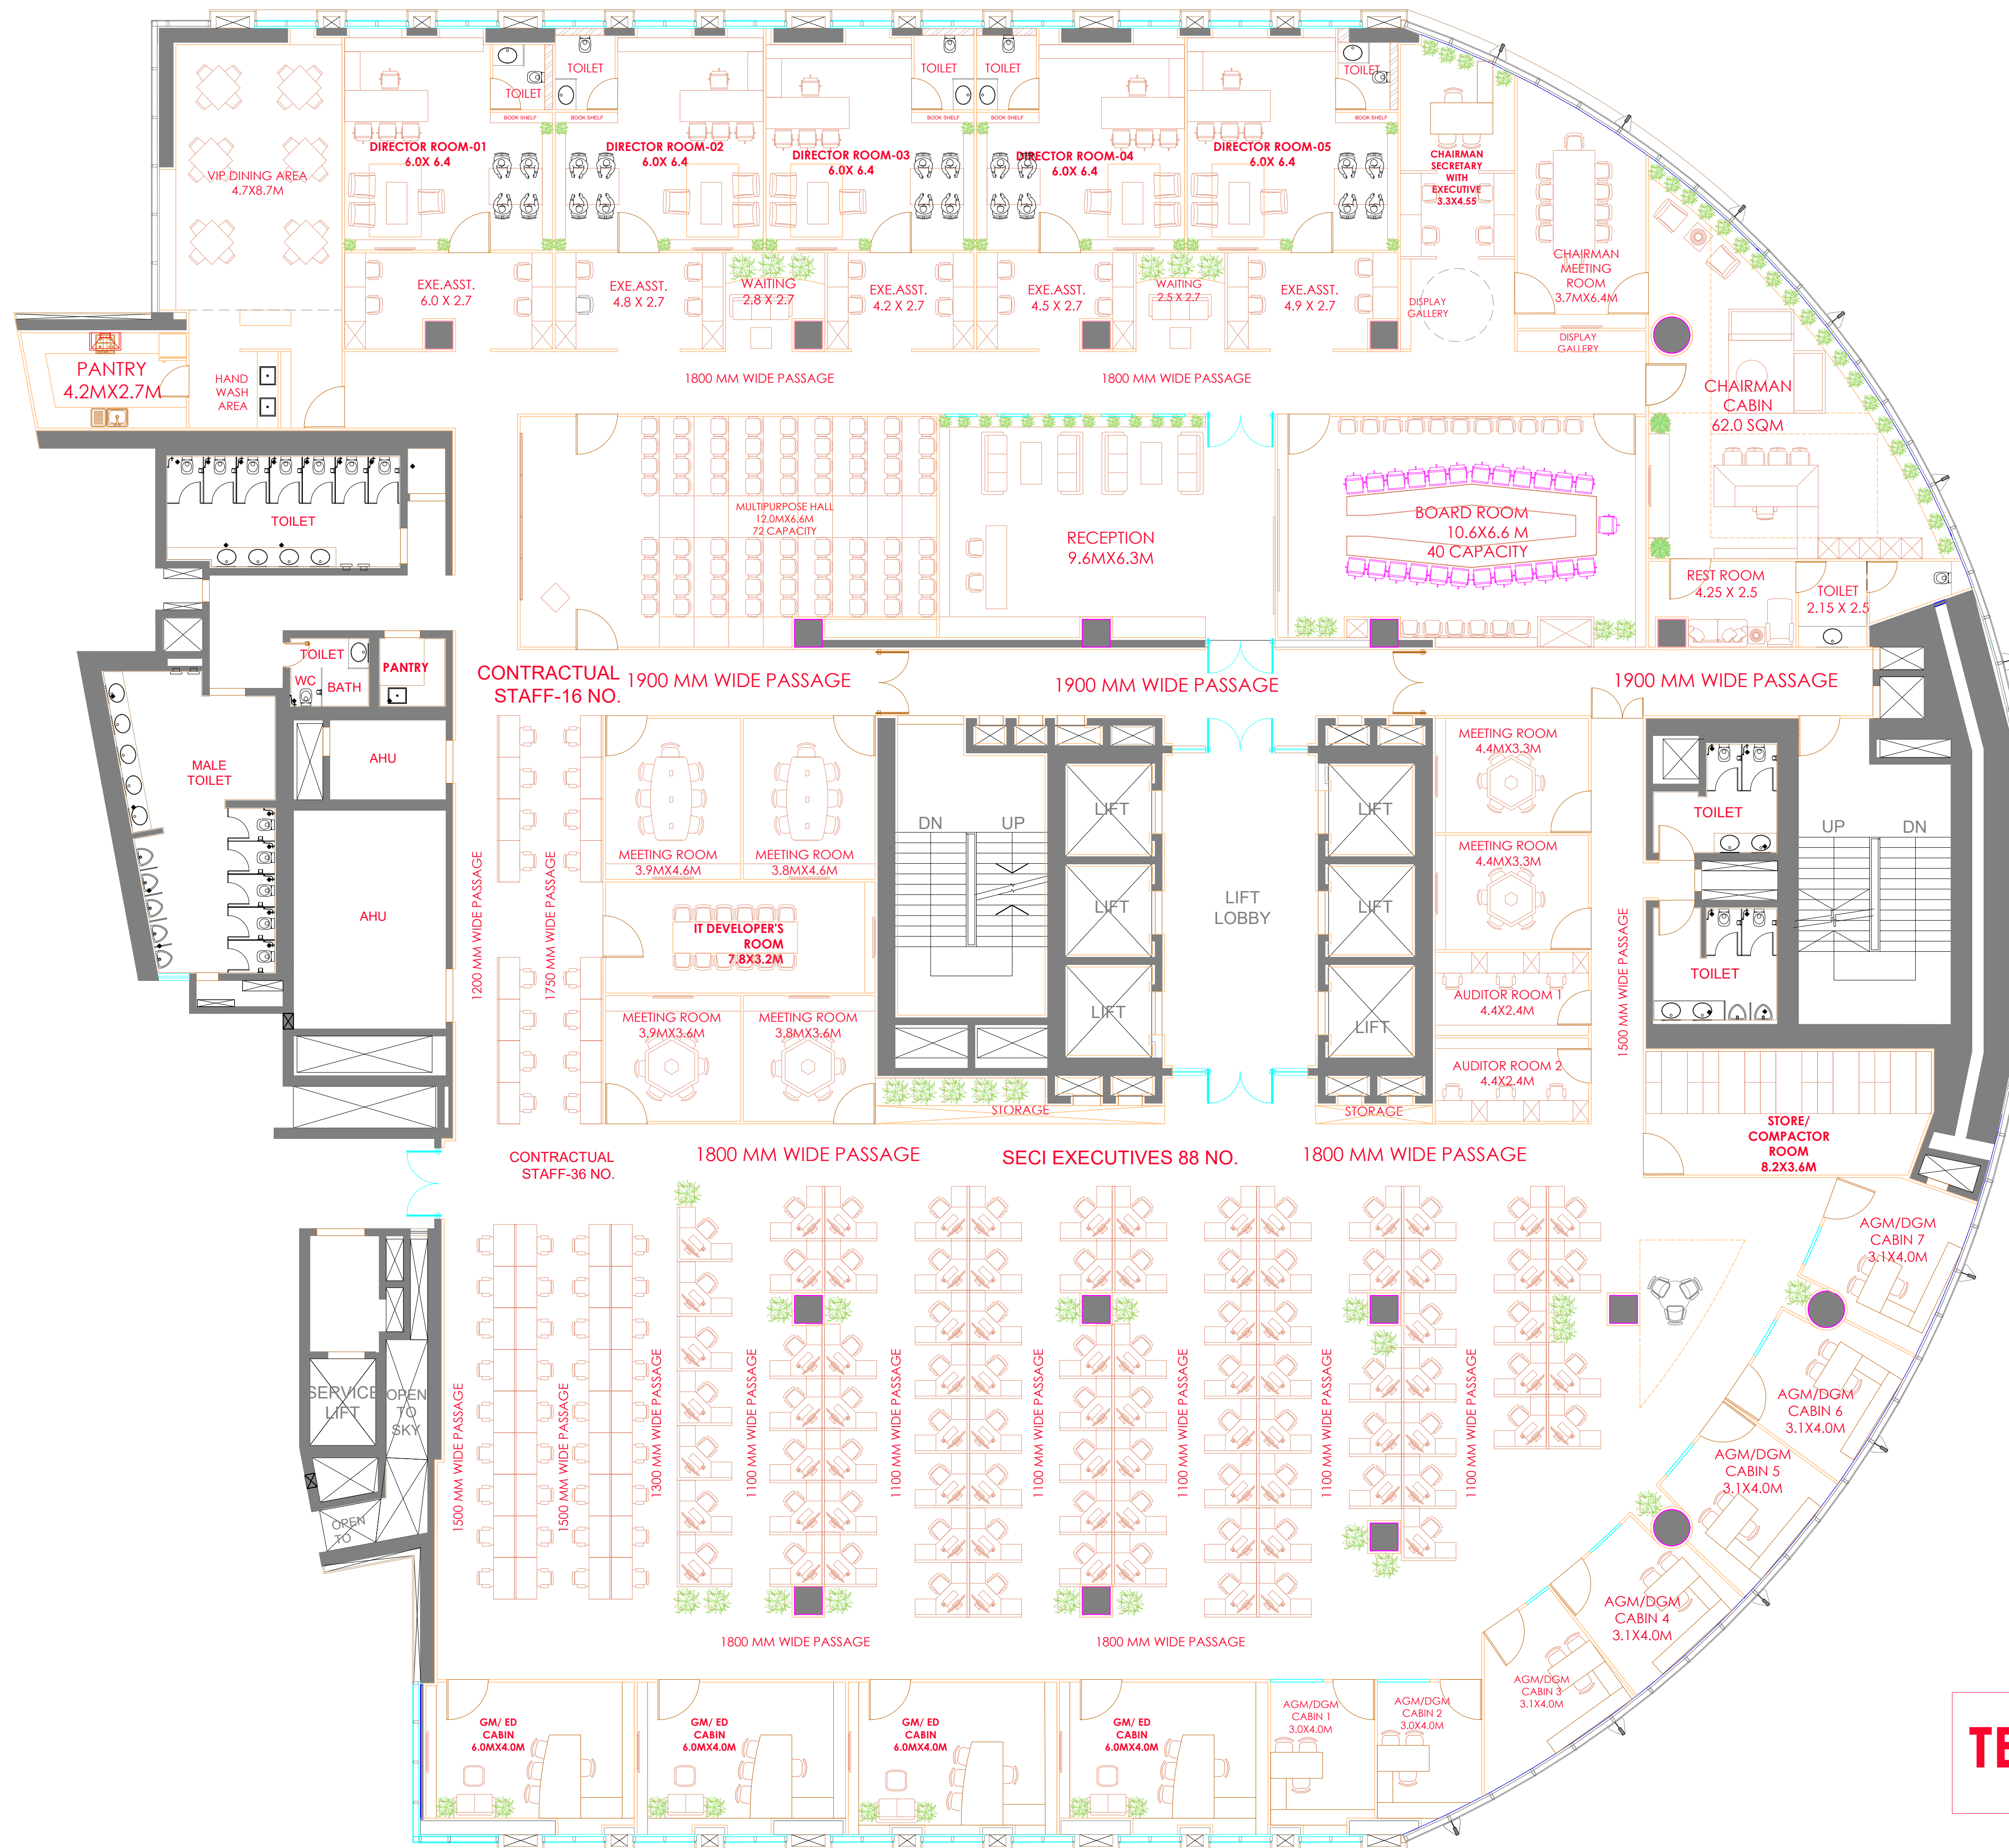



TENDER DRAWING

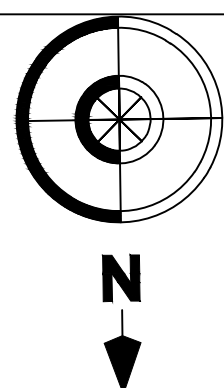


CLIENT:	PROJECT:	ARCHITECT:	DRAWING TITLE:	DATE :	SCALE :	SHEET
SOLAR ENERGY CORPORATION OF INDIA (SECI)	ARCHITECTURAL AND ENGINEERING CONSULTANCY SERVICES FOR INTERIOR WORKS AT TOWER-F 2nd & 3rd FLOOR ,NAUROJI NAGAR, NBCC DELHI	ATKV CONSULTANTS PVT. LTD. E-107 (LOWER GROUND FLOOR) G.K.-II NEW DELHI-110048 PH.NO. 40536580,29214906 TEL. FAX: 29214906	THIRD FLOOR INTERIOR LAYOUT	24-02-2025	NTS	A1
			DRAWN BY : AKANKSHA	DRAWING NO: SECI-INT-TF(01)		

  LEGEND :

S.NO.	DESCRIPTION
	CARPET FLOORING
	ITALIAN MARBLE FLOORING
	ITALIAN MARBLE 2 FLOORING
	CERAMIC TILES
	ENGINEERED WOODEN FLOORING
	DESIGNER VITRIFIED TILES
	FALSE FLOORING OVER VITRIFIED TILES
	LAMINATE WOODEN FLOORING
	VITRIFIED TILES

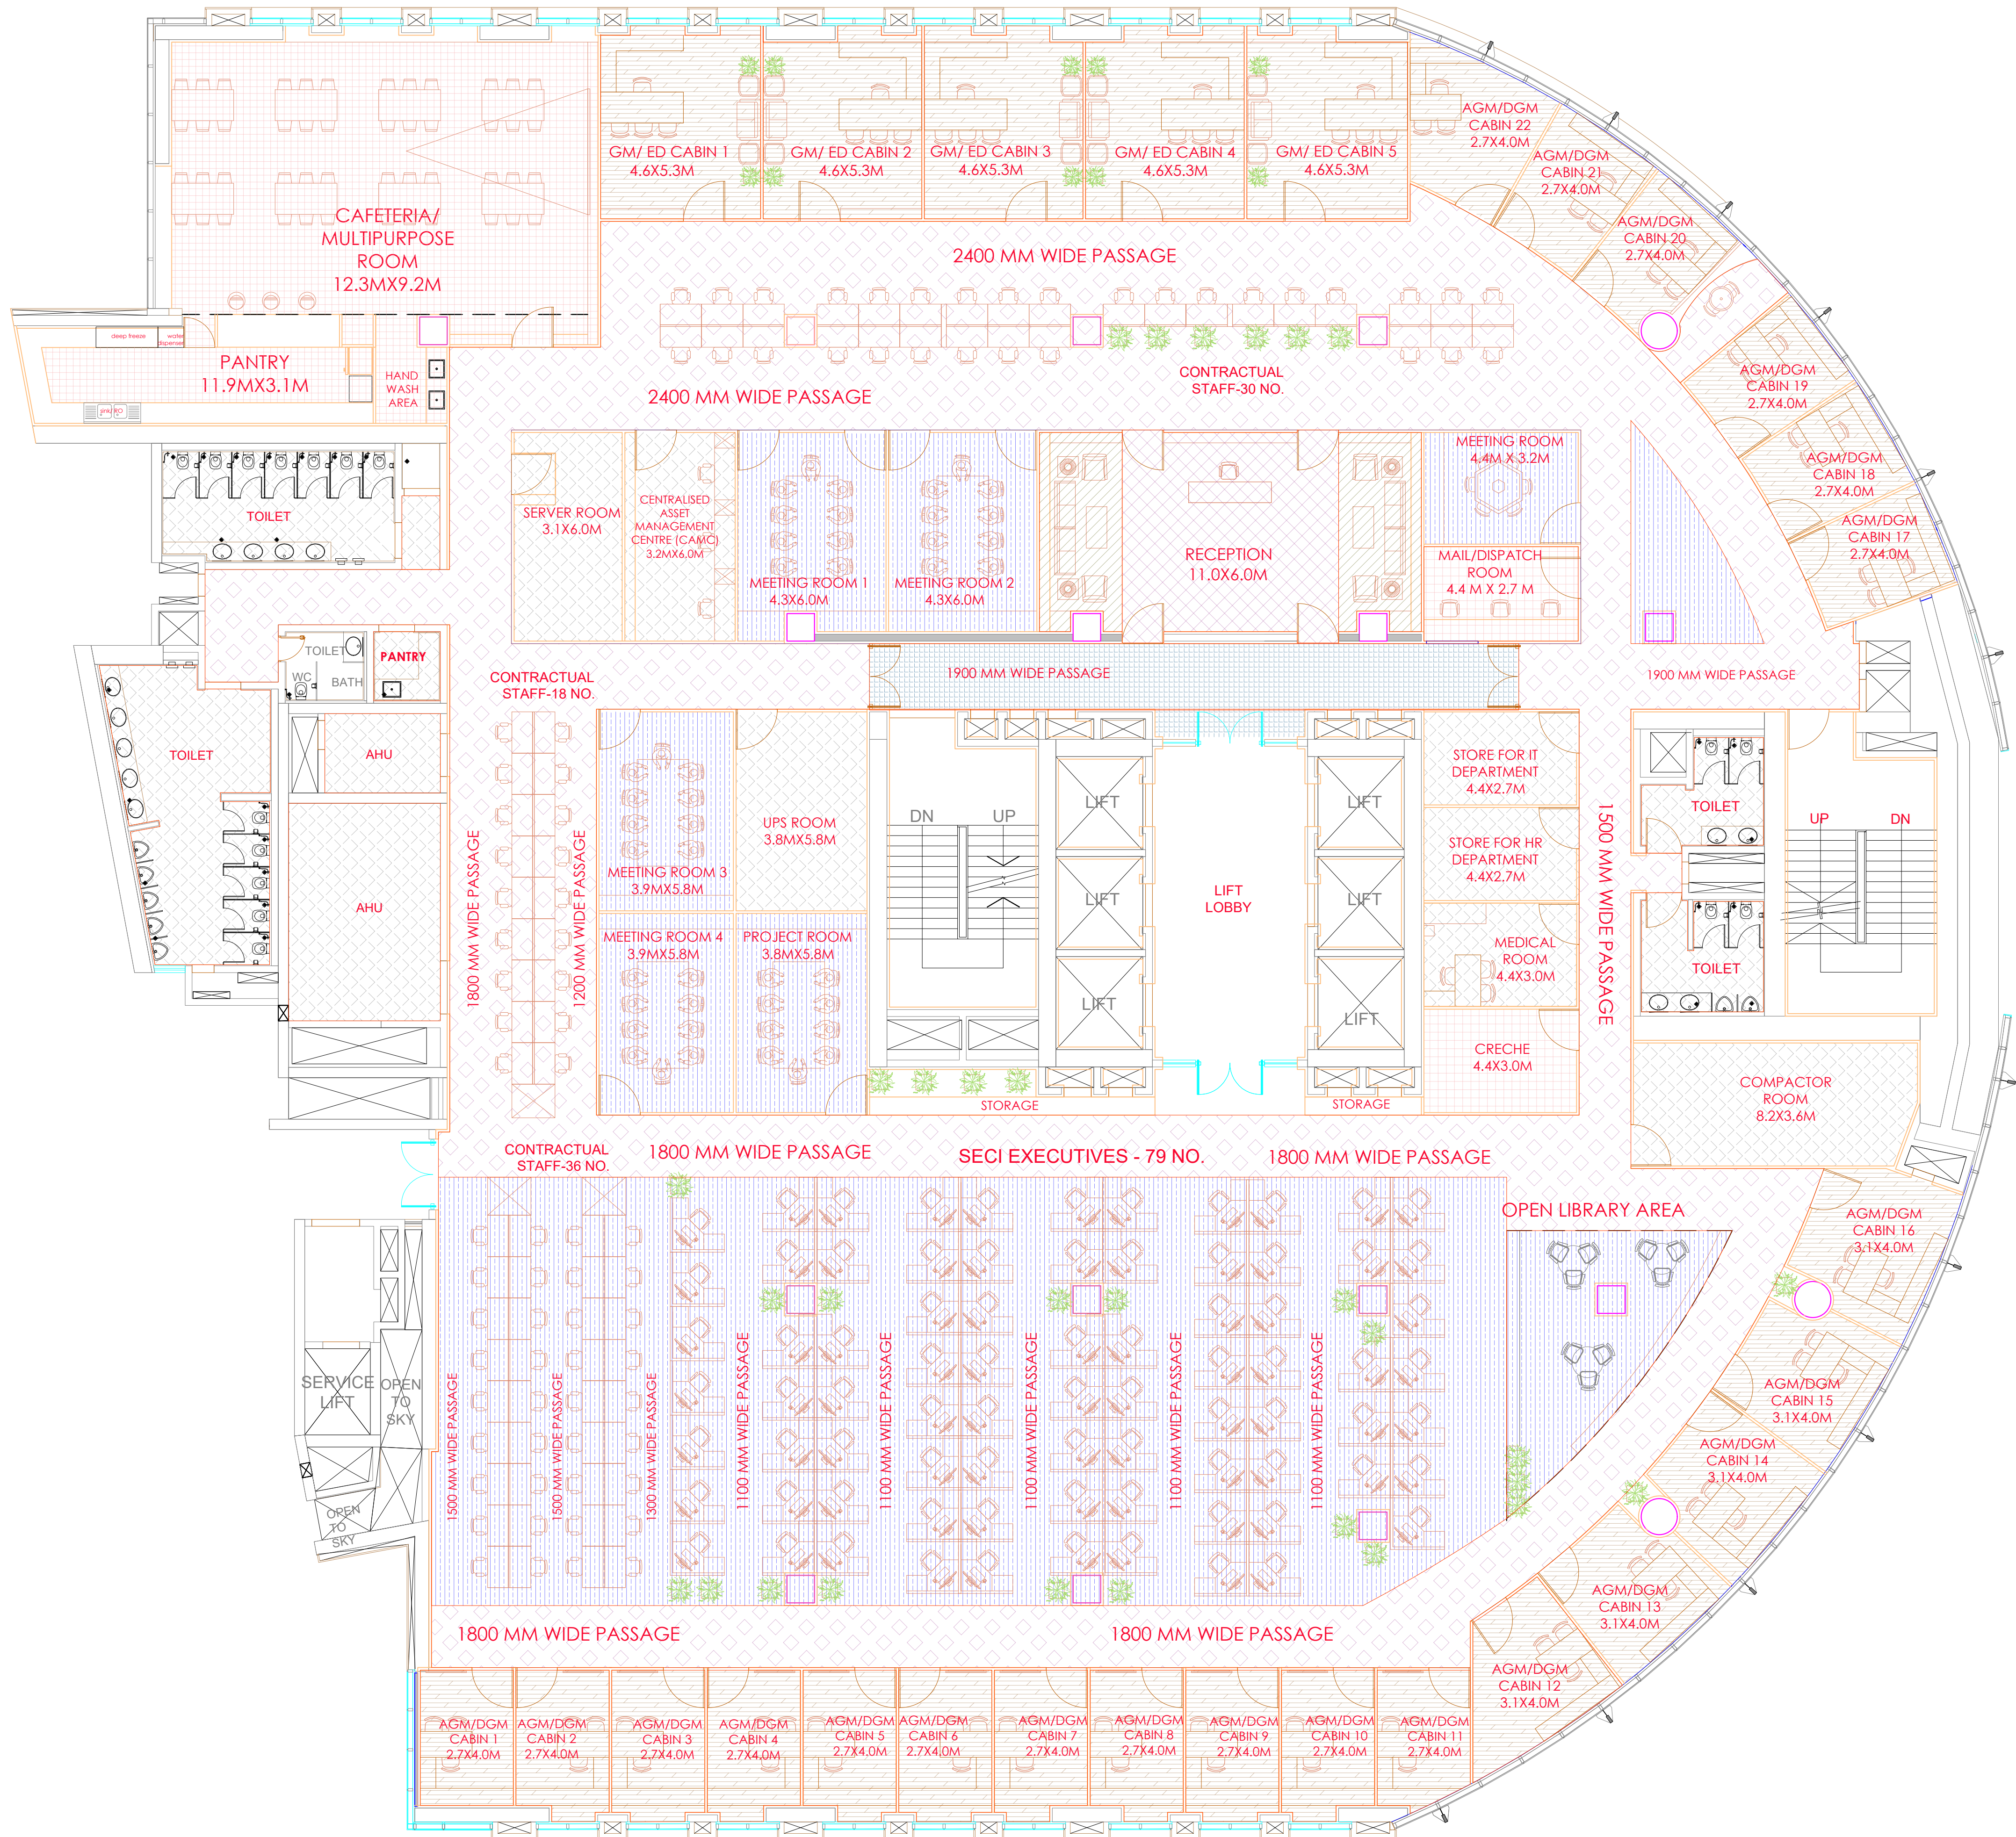

TENDER DRAWING

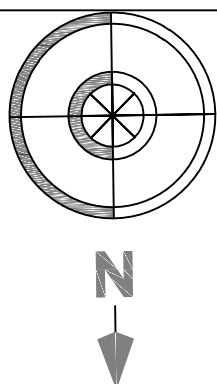

CLIENT:

SOLAR ENERGY CORPORATION OF INDIA (SECI)

PROJECT:

ARCHITECTURAL AND ENGINEERING CONSULTANCY
SERVICES FOR INTERIOR WORKS AT TOWER-F
2nd & 3rd FLOOR ,NAUROJI NAGAR, NBCC DELHI

ARCHITECT:

ATKV CONSULTANTS PVT. LTD.
E-107 (LOWER GROUND FLOOR) G.K.-II
NEW DELHI-110048
PH.NO. 40536580,29214906 TEL. FAX: 29214906

DRAWING TITLE:

SECOND FLOOR FLOORING LAYOUT

DRAWN BY : AKANKSHA

DATE :

24-02-2024

 
 
SCALE : SHEET


NTS

A1


DRAWING NO:SECI-INT-SF(03)

LEGEND :


S.NO.	DESCRIPTION
	CARPET FLOORING
	ITALIAN MARBLE FLOORING
	ITALIAN MARBLE 2 FLOORING
	CERAMIC TILES
	ENGINEERED WOODEN FLOORING
	VITRIFIED TILES
	FALSE FLOORING OVER VITRIFIED TILES
	LAMINATE WOODEN FLOORING
	VITRIFIED TILES
	PATTERNED ENGINEERED WOOD

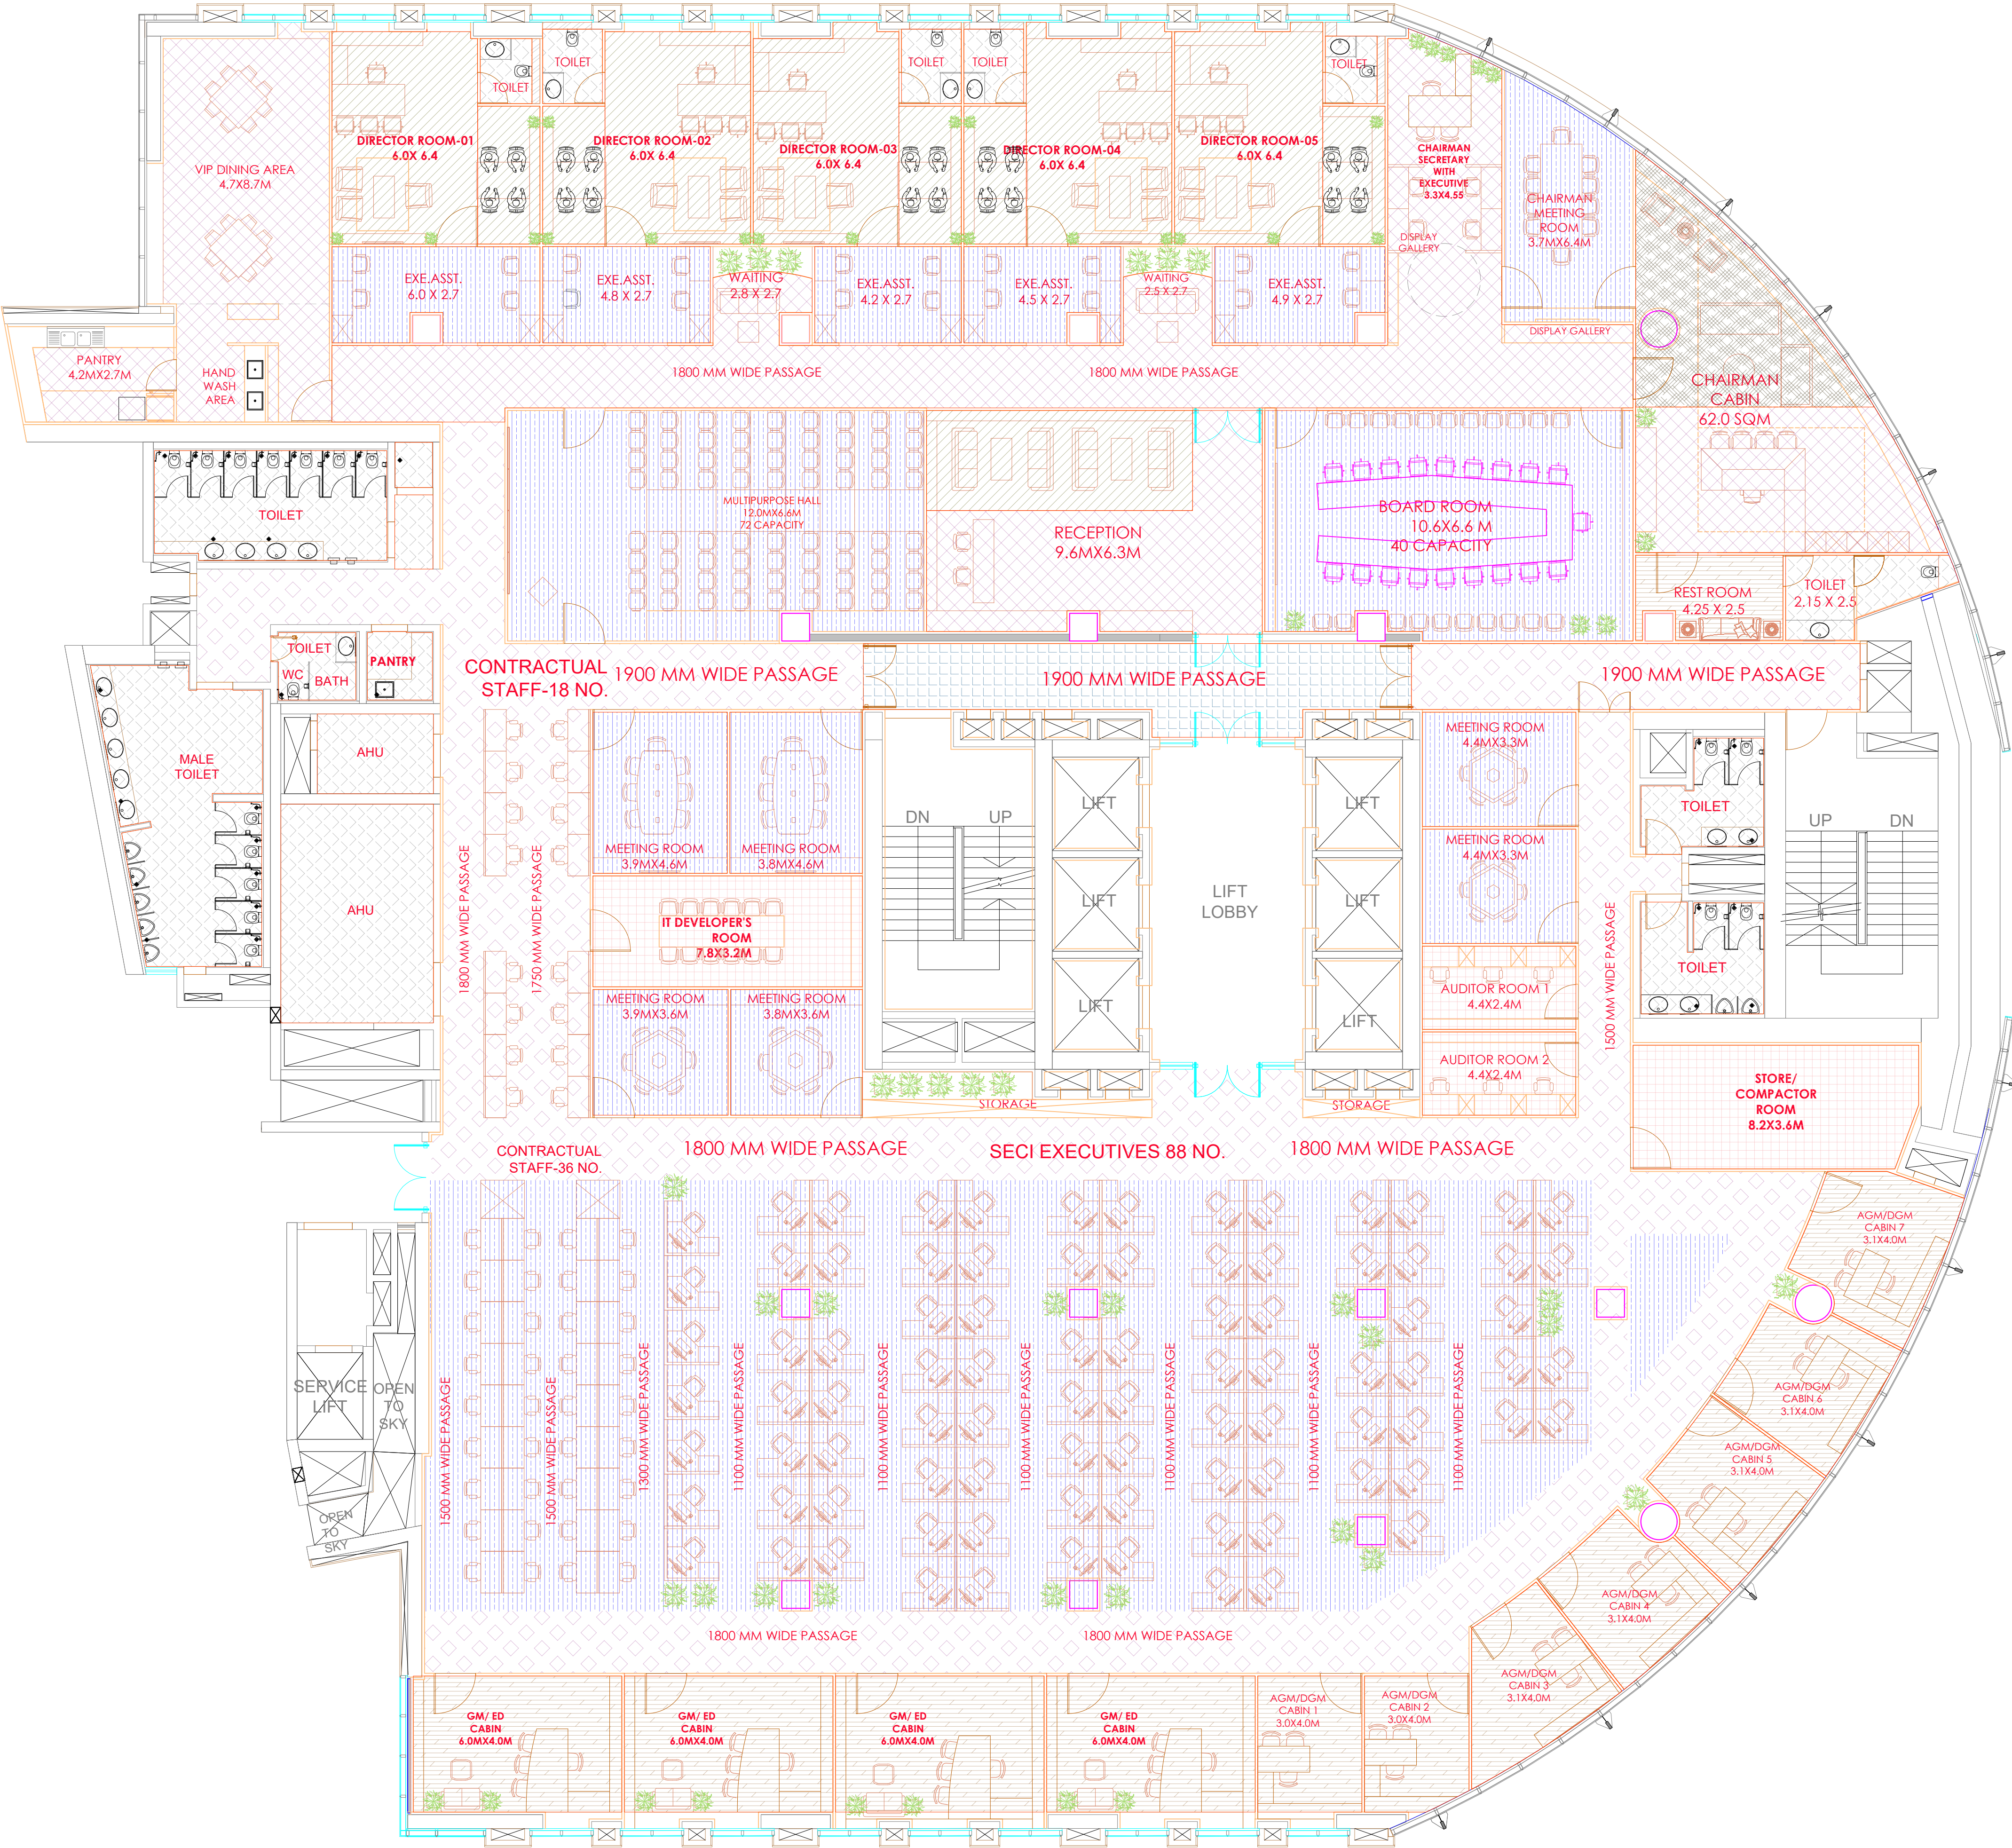

TENDER DRAWING

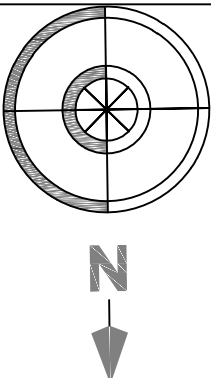

CLIENT:	PROJECT:	ARCHITECT:	DRAWING TITLE:	DATE :	SCALE :	SHEET
SOLAR ENERGY CORPORATION OF INDIA (SECI)	ARCHITECTURAL AND ENGINEERING CONSULTANCY SERVICES FOR INTERIOR WORKS AT TOWER-F 2nd & 3rd FLOOR ,NAUROJI NAGAR, NBCC DELHI	ATKV CONSULTANTS PVT. LTD. E-107 (LOWER GROUND FLOOR) G.K.-II NEW DELHI-110048 PH.NO. 40536580,29214906 TEL. FAX: 29214906	THIRD FLOOR FLOORING LAYOUT	24-02-2024	NTS	A1
DRAWN BY : AKANKSHA				DRAWING NO: SECI-INT-TF(03)		

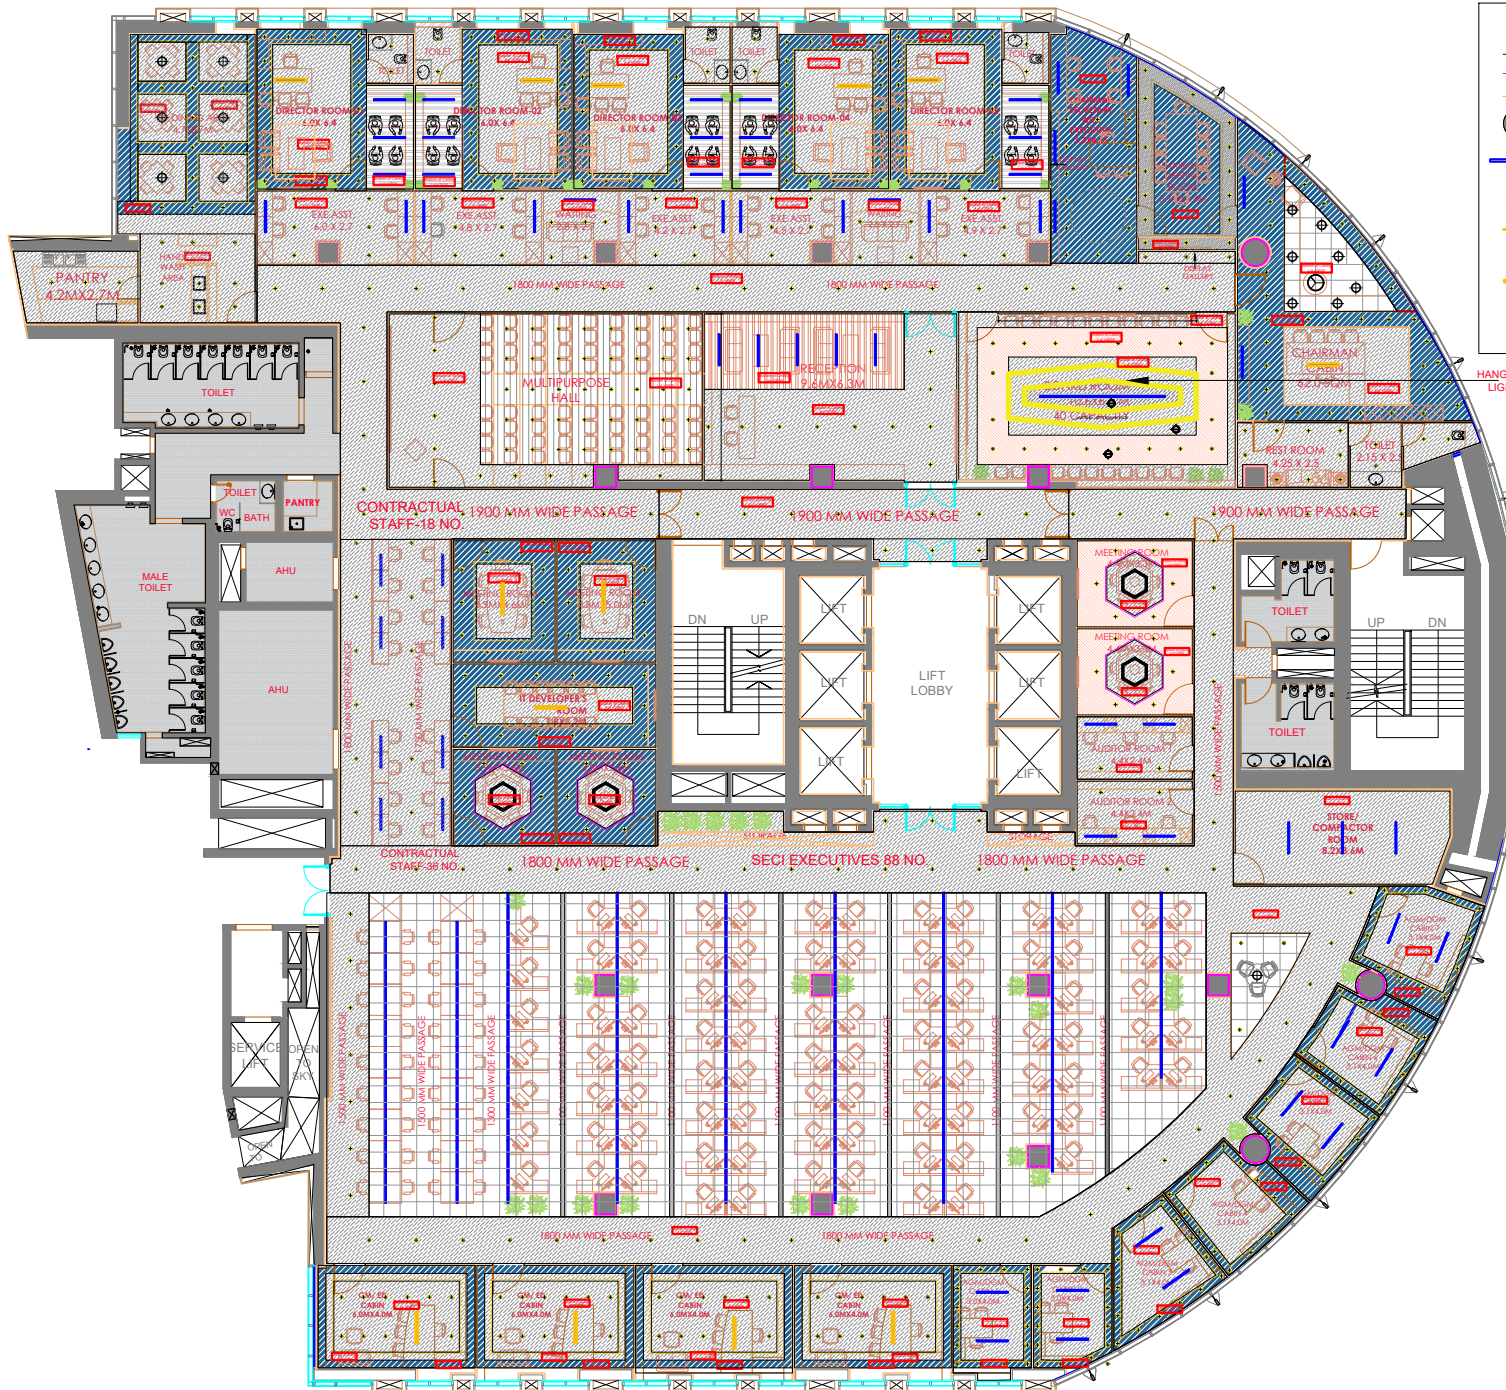


- CHANDELIER
 - FOCUS LIGHT
 - COVE LIGHT (5 W/M)
 - COVE LIGHT (5 W/M)
 - HANGING LIGHT
 - 36W LED LINEAR LIGHT 1200mm Length
 - DECORATIVE HANGING LIGHT
 - DECORATIVE LIGHT
 - CEILING LIGHT
 - DESIGNER HANGING SLIM LED TUBE
 - 36W-LED 600x600 Light
 - HANGING Light
- VENEER CEILING OVER MDF
 - LINEAR OPEN CELL CEILING
 - ALUMINIUM/UPVC WOOD FINISH LOUVERS
 - UPVC BAFFLE CEILING
 - OPEN CELL CEILING
 - WOODEN OPEN CELL CEILING
 - MDF CEILING
 - VENEER LAMINATE CEILING OVER MDF
 - GYPSUM CEILING

TENDER DRAWING



CLIENT:	PROJECT:	ARCHITECT:	DRAWING TITLE:	DATE :	SCALE :	SHEET
SOLAR ENERGY CORPORATION OF INDIA (SECI)	ARCHITECTURAL AND ENGINEERING CONSULTANCY SERVICES FOR INTERIOR WORKS AT TOWER-F 2nd & 3rd FLOOR ,NAUROJI NAGAR, NBCC DELHI	ATKV CONSULTANTS PVT. LTD. E-107 (LOWER GROUND FLOOR) G.K.-II NEW DELHI-110048 PH.NO. 40536580,29214906 TEL. FAX: 29214906	THIRD FLOOR FALSE CEILING LAYOUT	07-03-2025	NTS	A1
DRAWN BY : AR.AKANKSHA				DRAWING NO: SECI-INT-TF(02)		

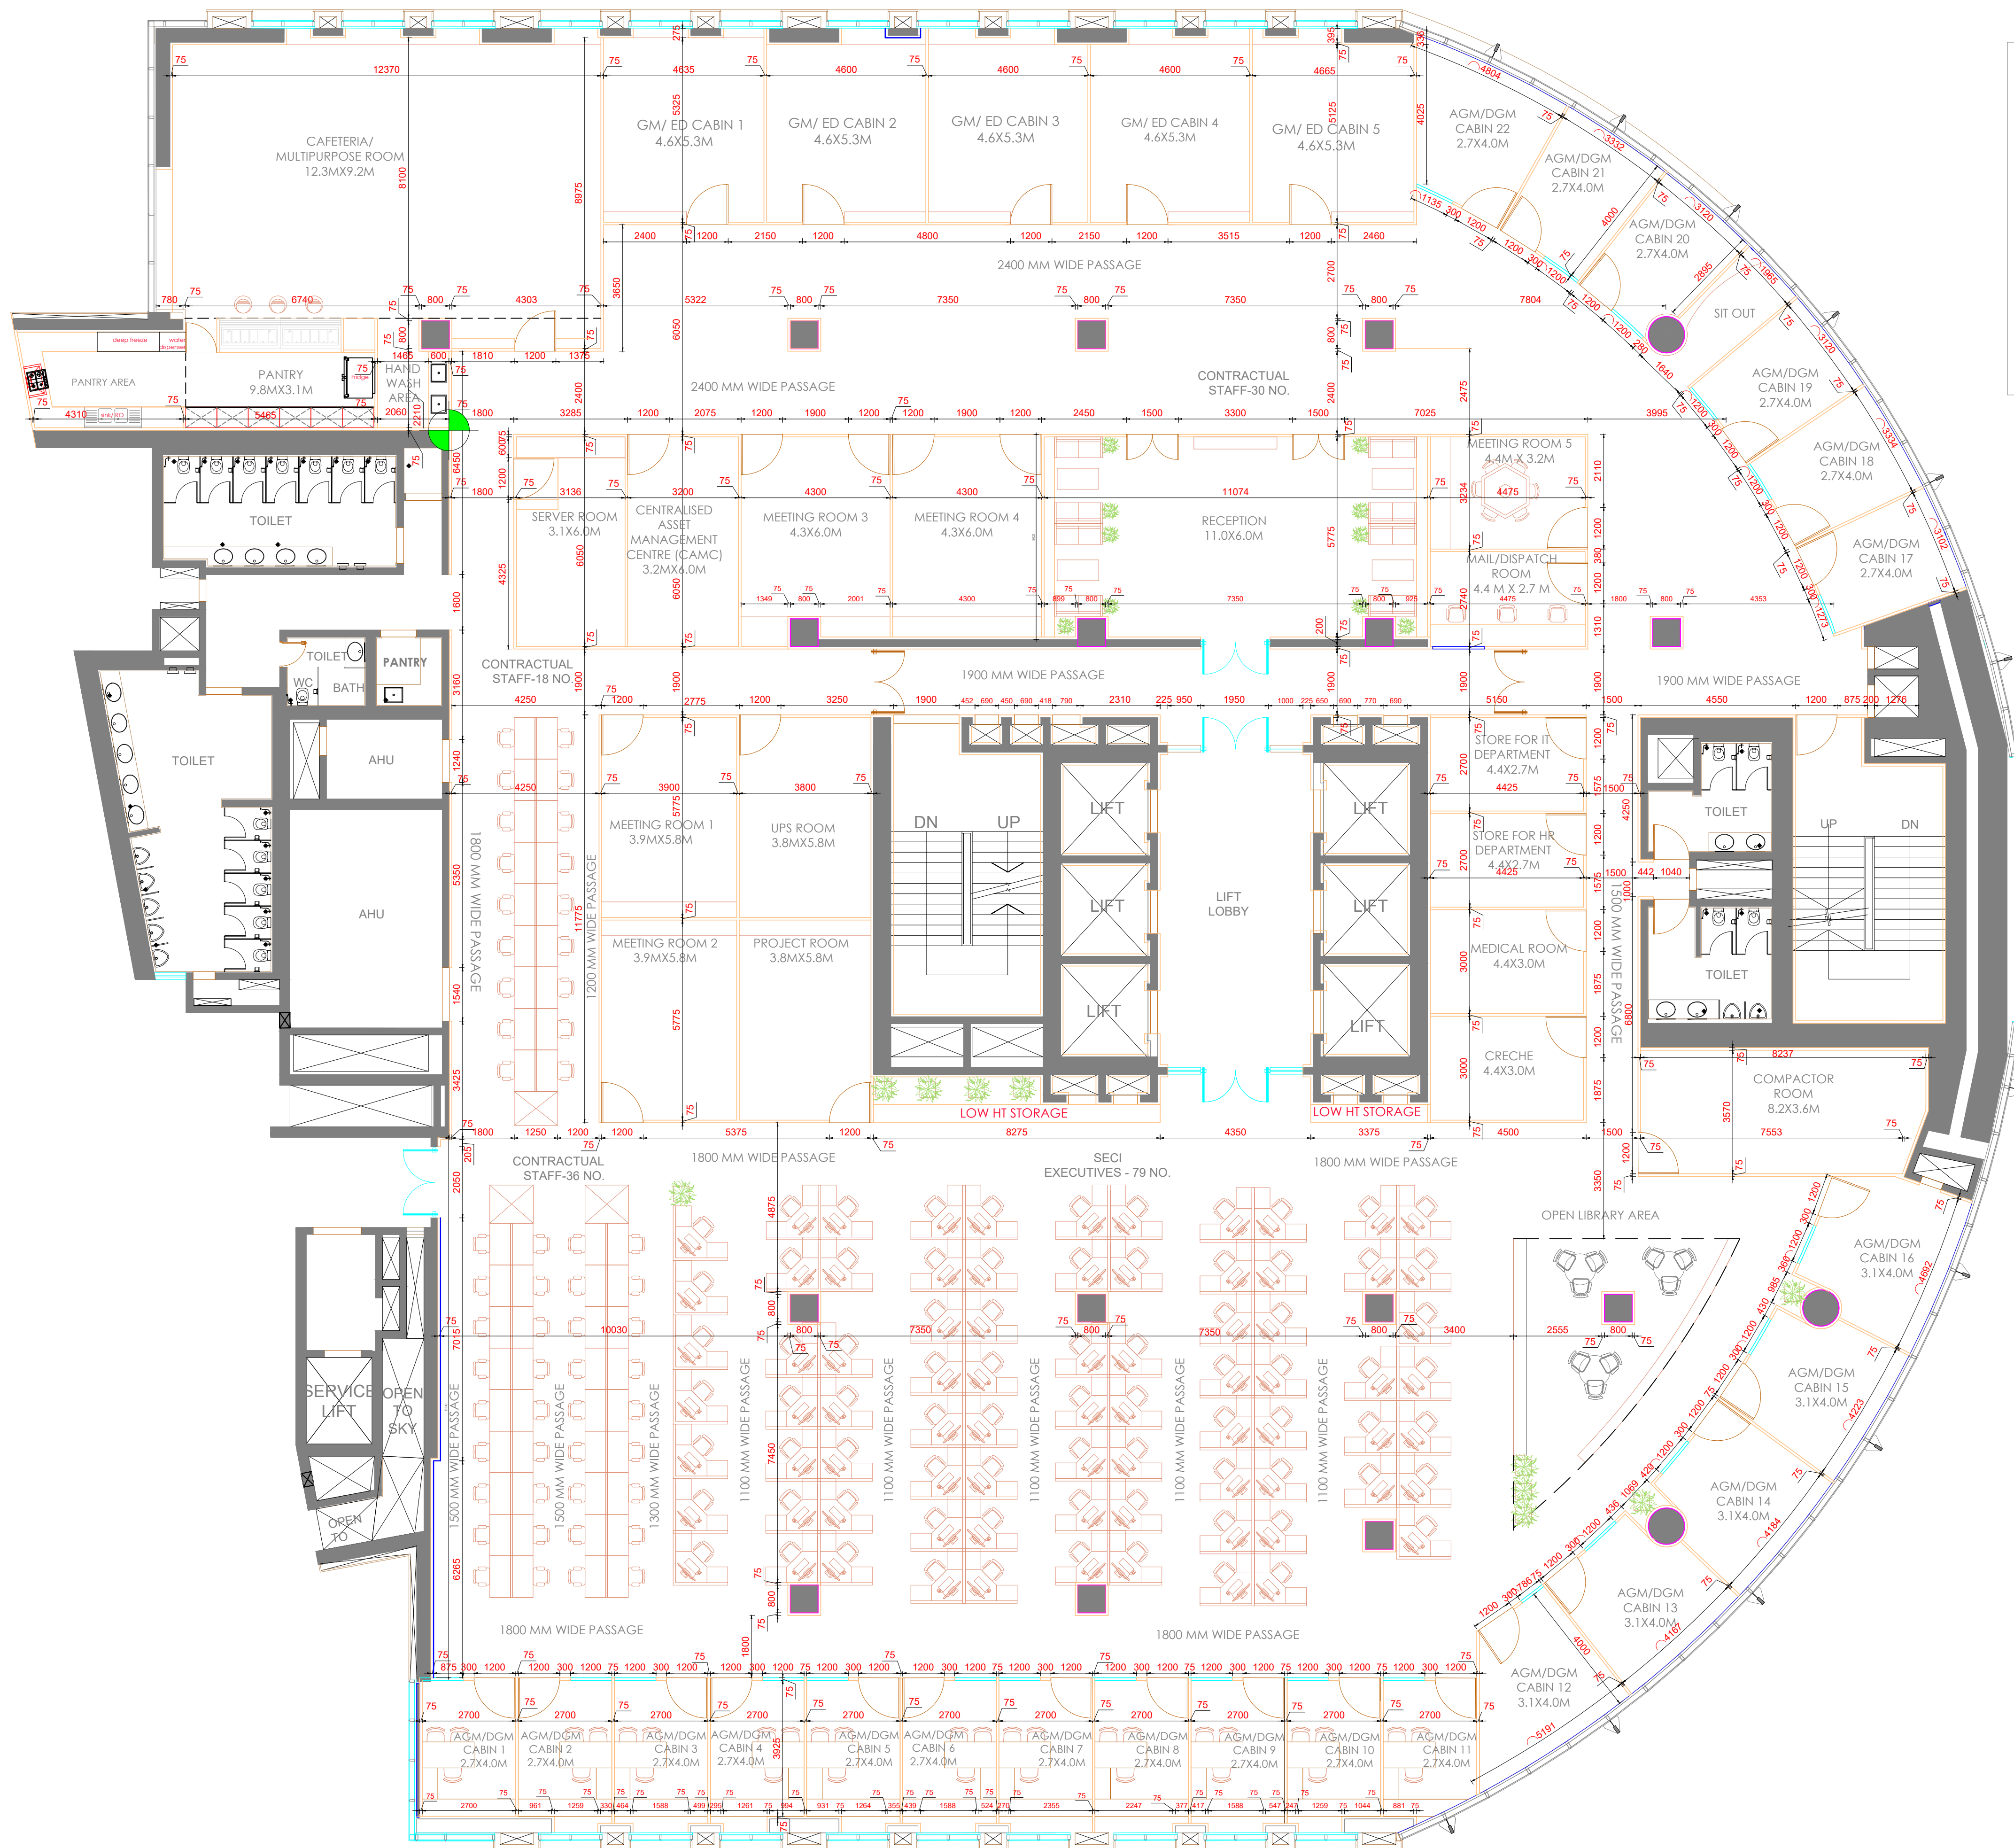


FULL HEIGHT PARTITION UPTO FALSE CEILING LVL

LOW HEIGHT 1200MM HIGH PARTITION


PARTITION WITH GLASS WINDOW

STARTING POINT


TENDER DRAWING

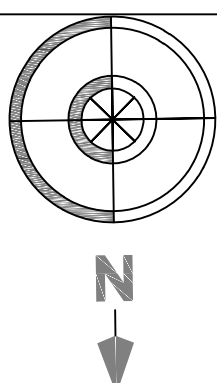

CLIENT:	PROJECT:	ARCHITECT:	DRAWING TITLE:	DATE :	SCALE :	SHEET
SOLAR ENERGY CORPORATION OF INDIA (SECI)	ARCHITECTURAL AND ENGINEERING CONSULTANCY SERVICES FOR INTERIOR WORKS AT TOWER-F 2nd & 3rd FLOOR ,NAUROJI NAGAR, NBCC DELHI	ATKV CONSULTANTS PVT. LTD. E-107 (LOWER GROUND FLOOR) G.K.-II NEW DELHI-110048 PH.NO. 40536580,29214906 TEL. FAX: 29214906	SECOND FLOOR PARTITION LAYOUT	16-02-2025	NTS	A1
			DRAWN BY : AKANKSHA	DRAWING NO: SECI-INT-SF(04)		

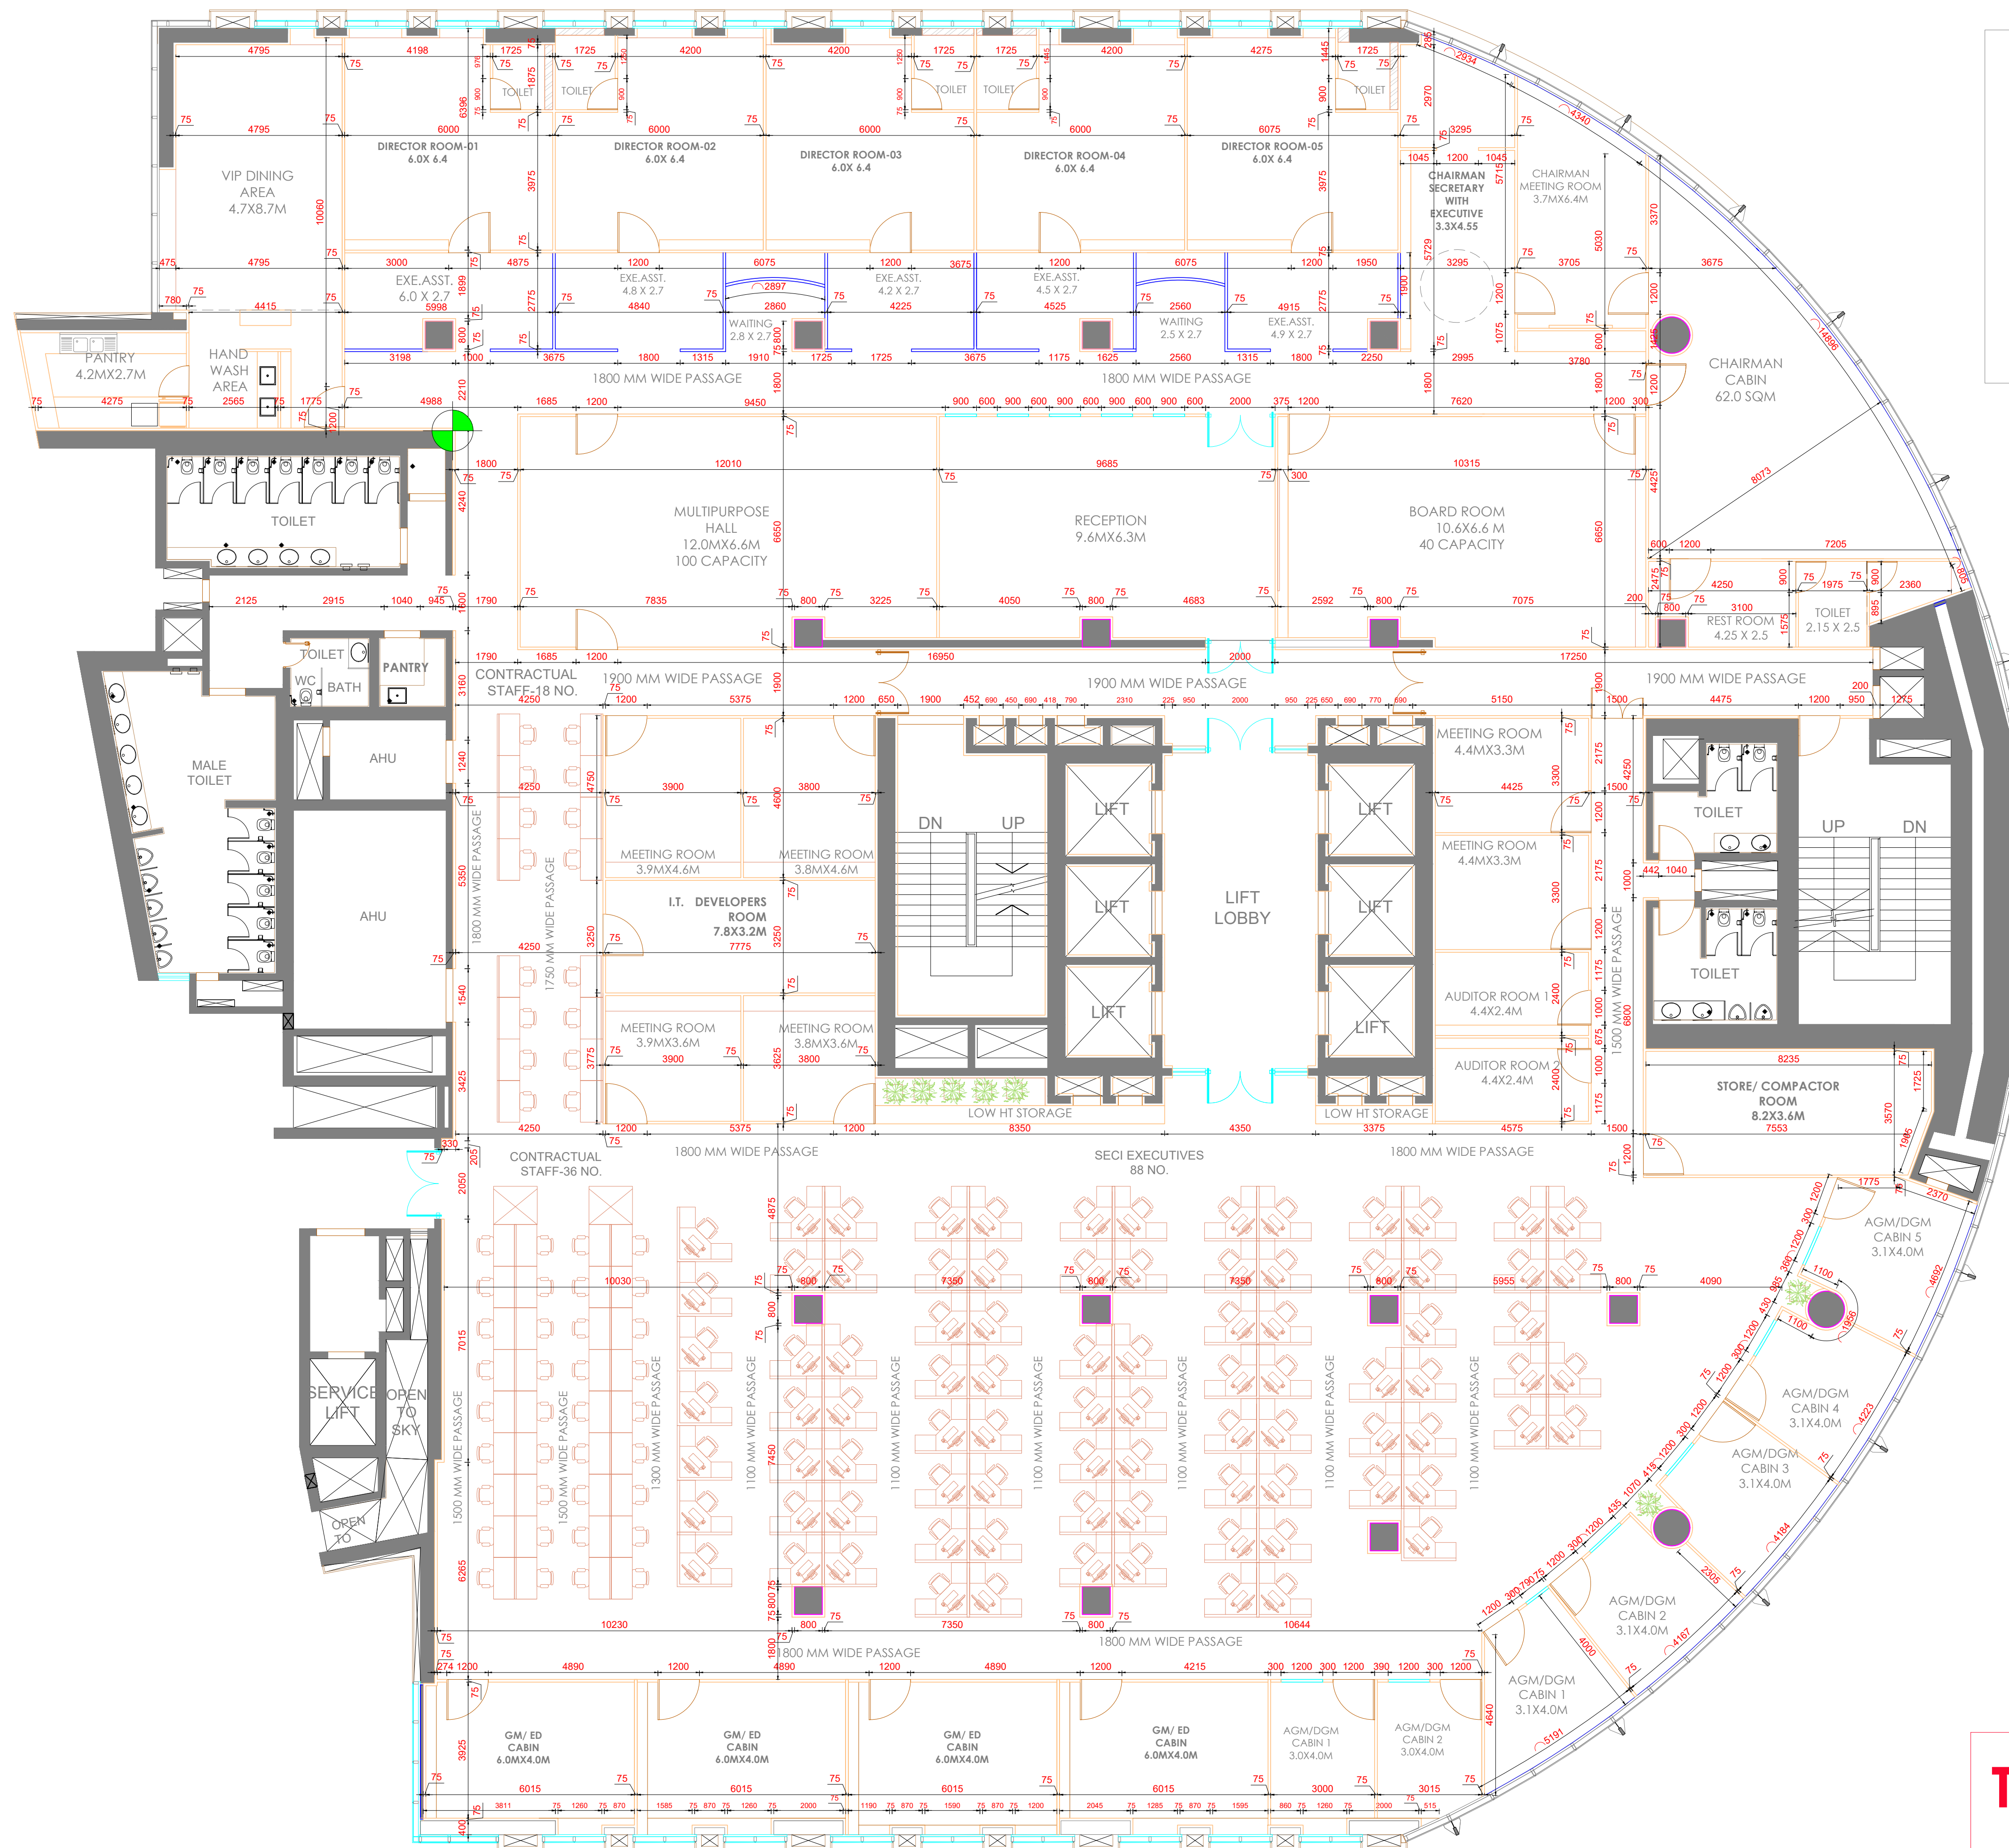


TENDER DRAWING

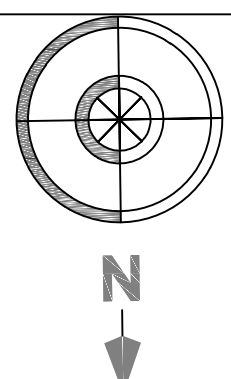


CLIENT:	PROJECT:	ARCHITECT:	DRAWING TITLE:	DATE :	SCALE :	SHEET
SOLAR ENERGY CORPORATION OF INDIA (SECI)	ARCHITECTURAL AND ENGINEERING CONSULTANCY SERVICES FOR INTERIOR WORKS AT TOWER-F 2nd & 3rd FLOOR ,NAUROJI NAGAR, NBCC DELHI	ATKV CONSULTANTS PVT. LTD. E-107 (LOWER GROUND FLOOR) G.K.-II NEW DELHI-110048 PH.NO. 40536580,29214906 TEL. FAX: 29214906	THIRD FLOOR PARTITION LAYOUT	16-02-2025	NTS	A1
			DRAWN BY : AKANKSHA	DRAWING NO: SECI-INT-TF(04)		

EXISTING RISING MAIN PROVISION

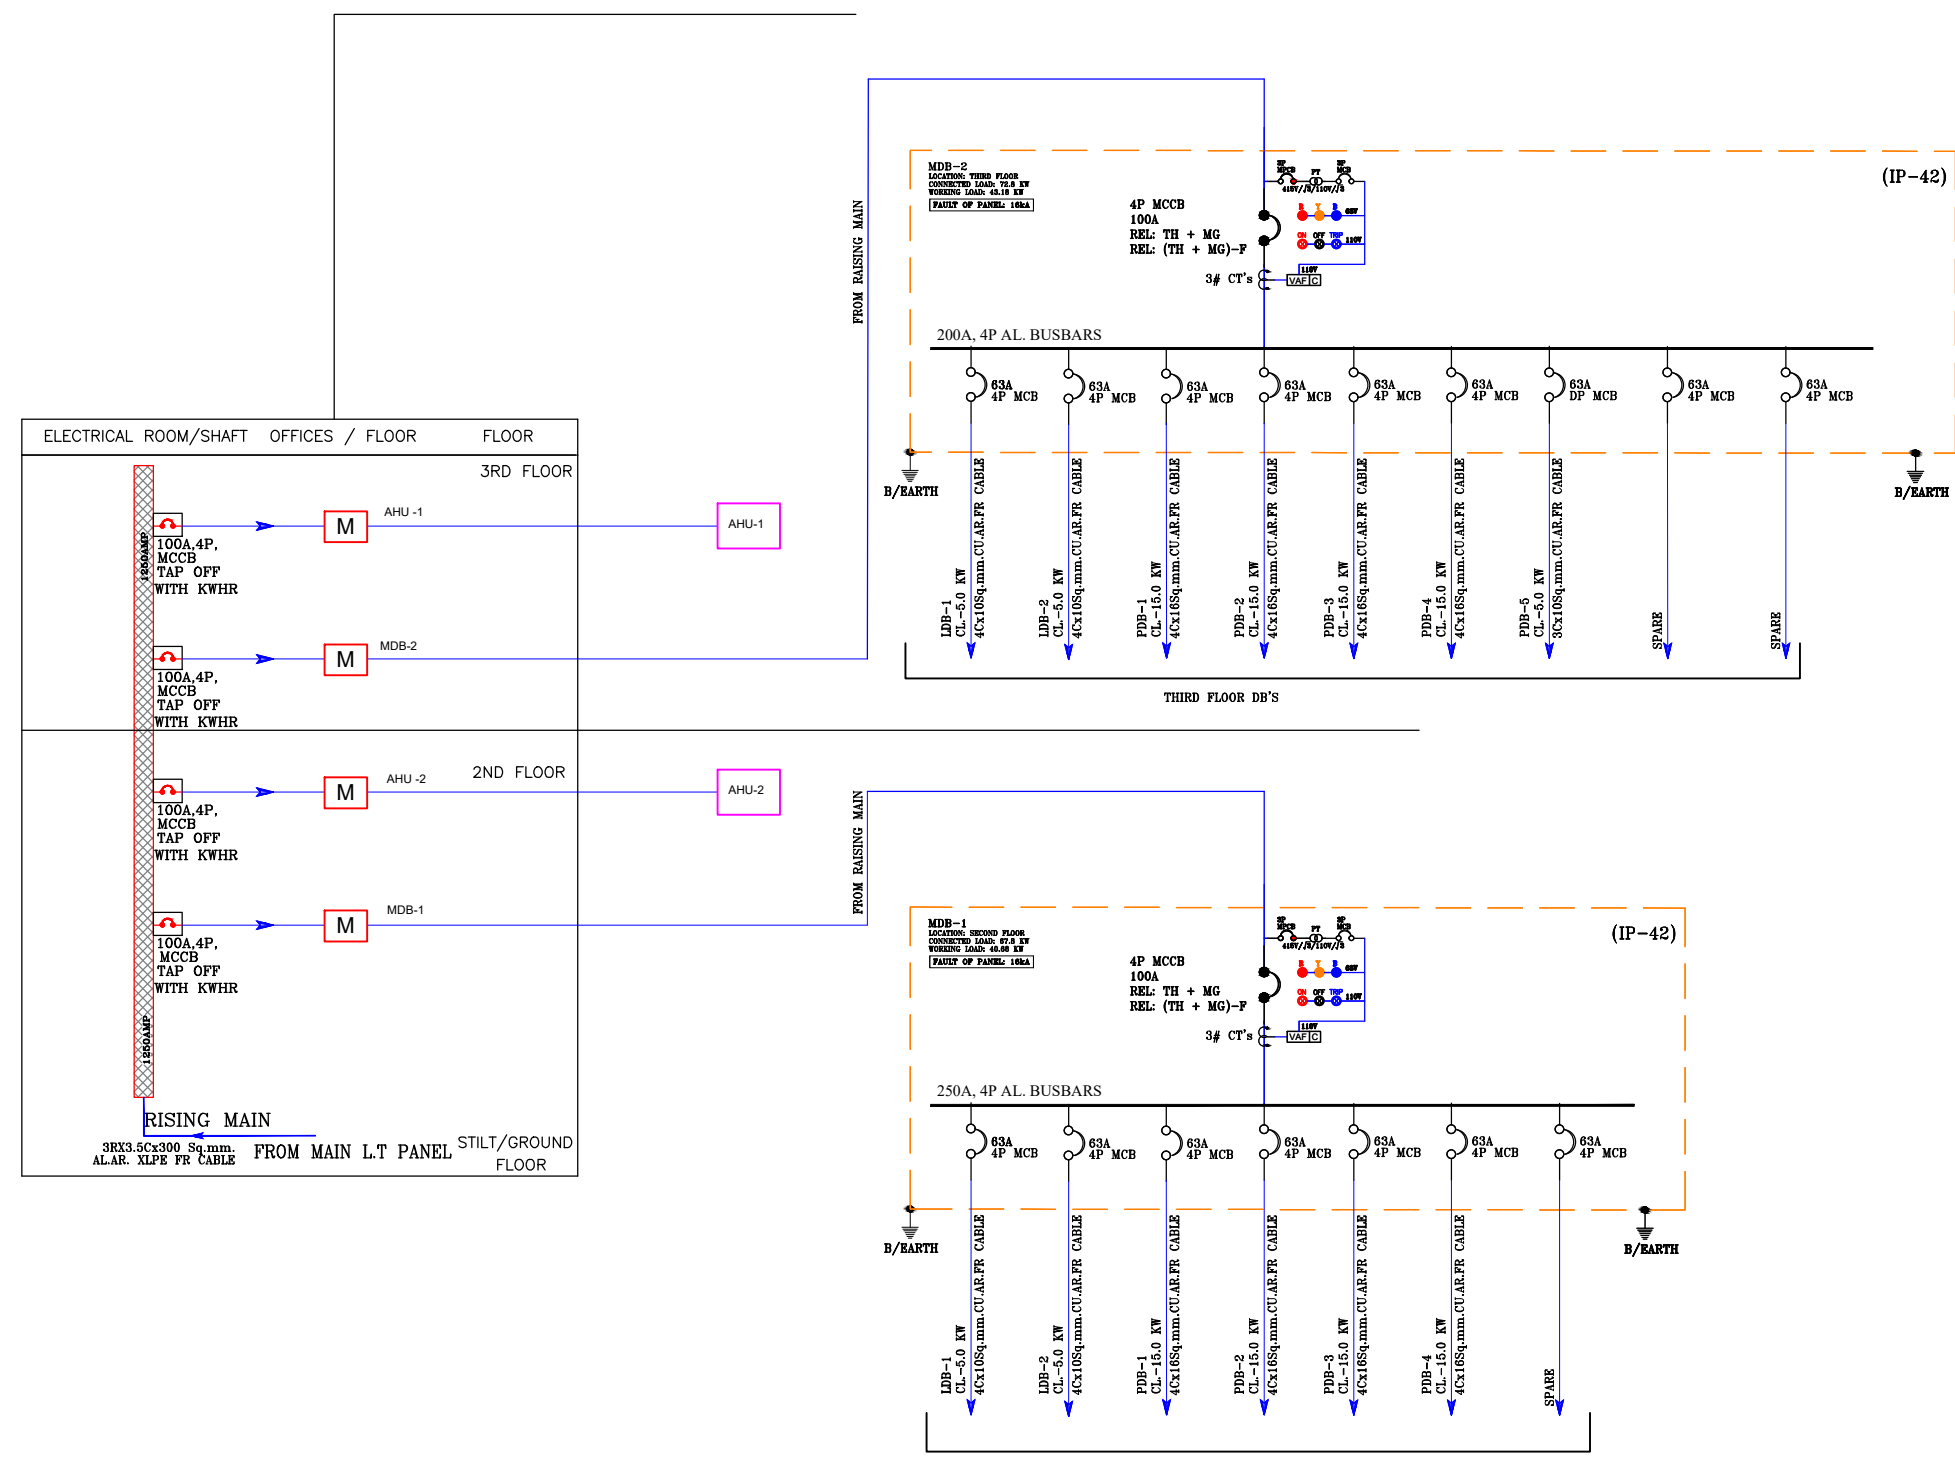

EXISTING RISING MAIN PROVISION

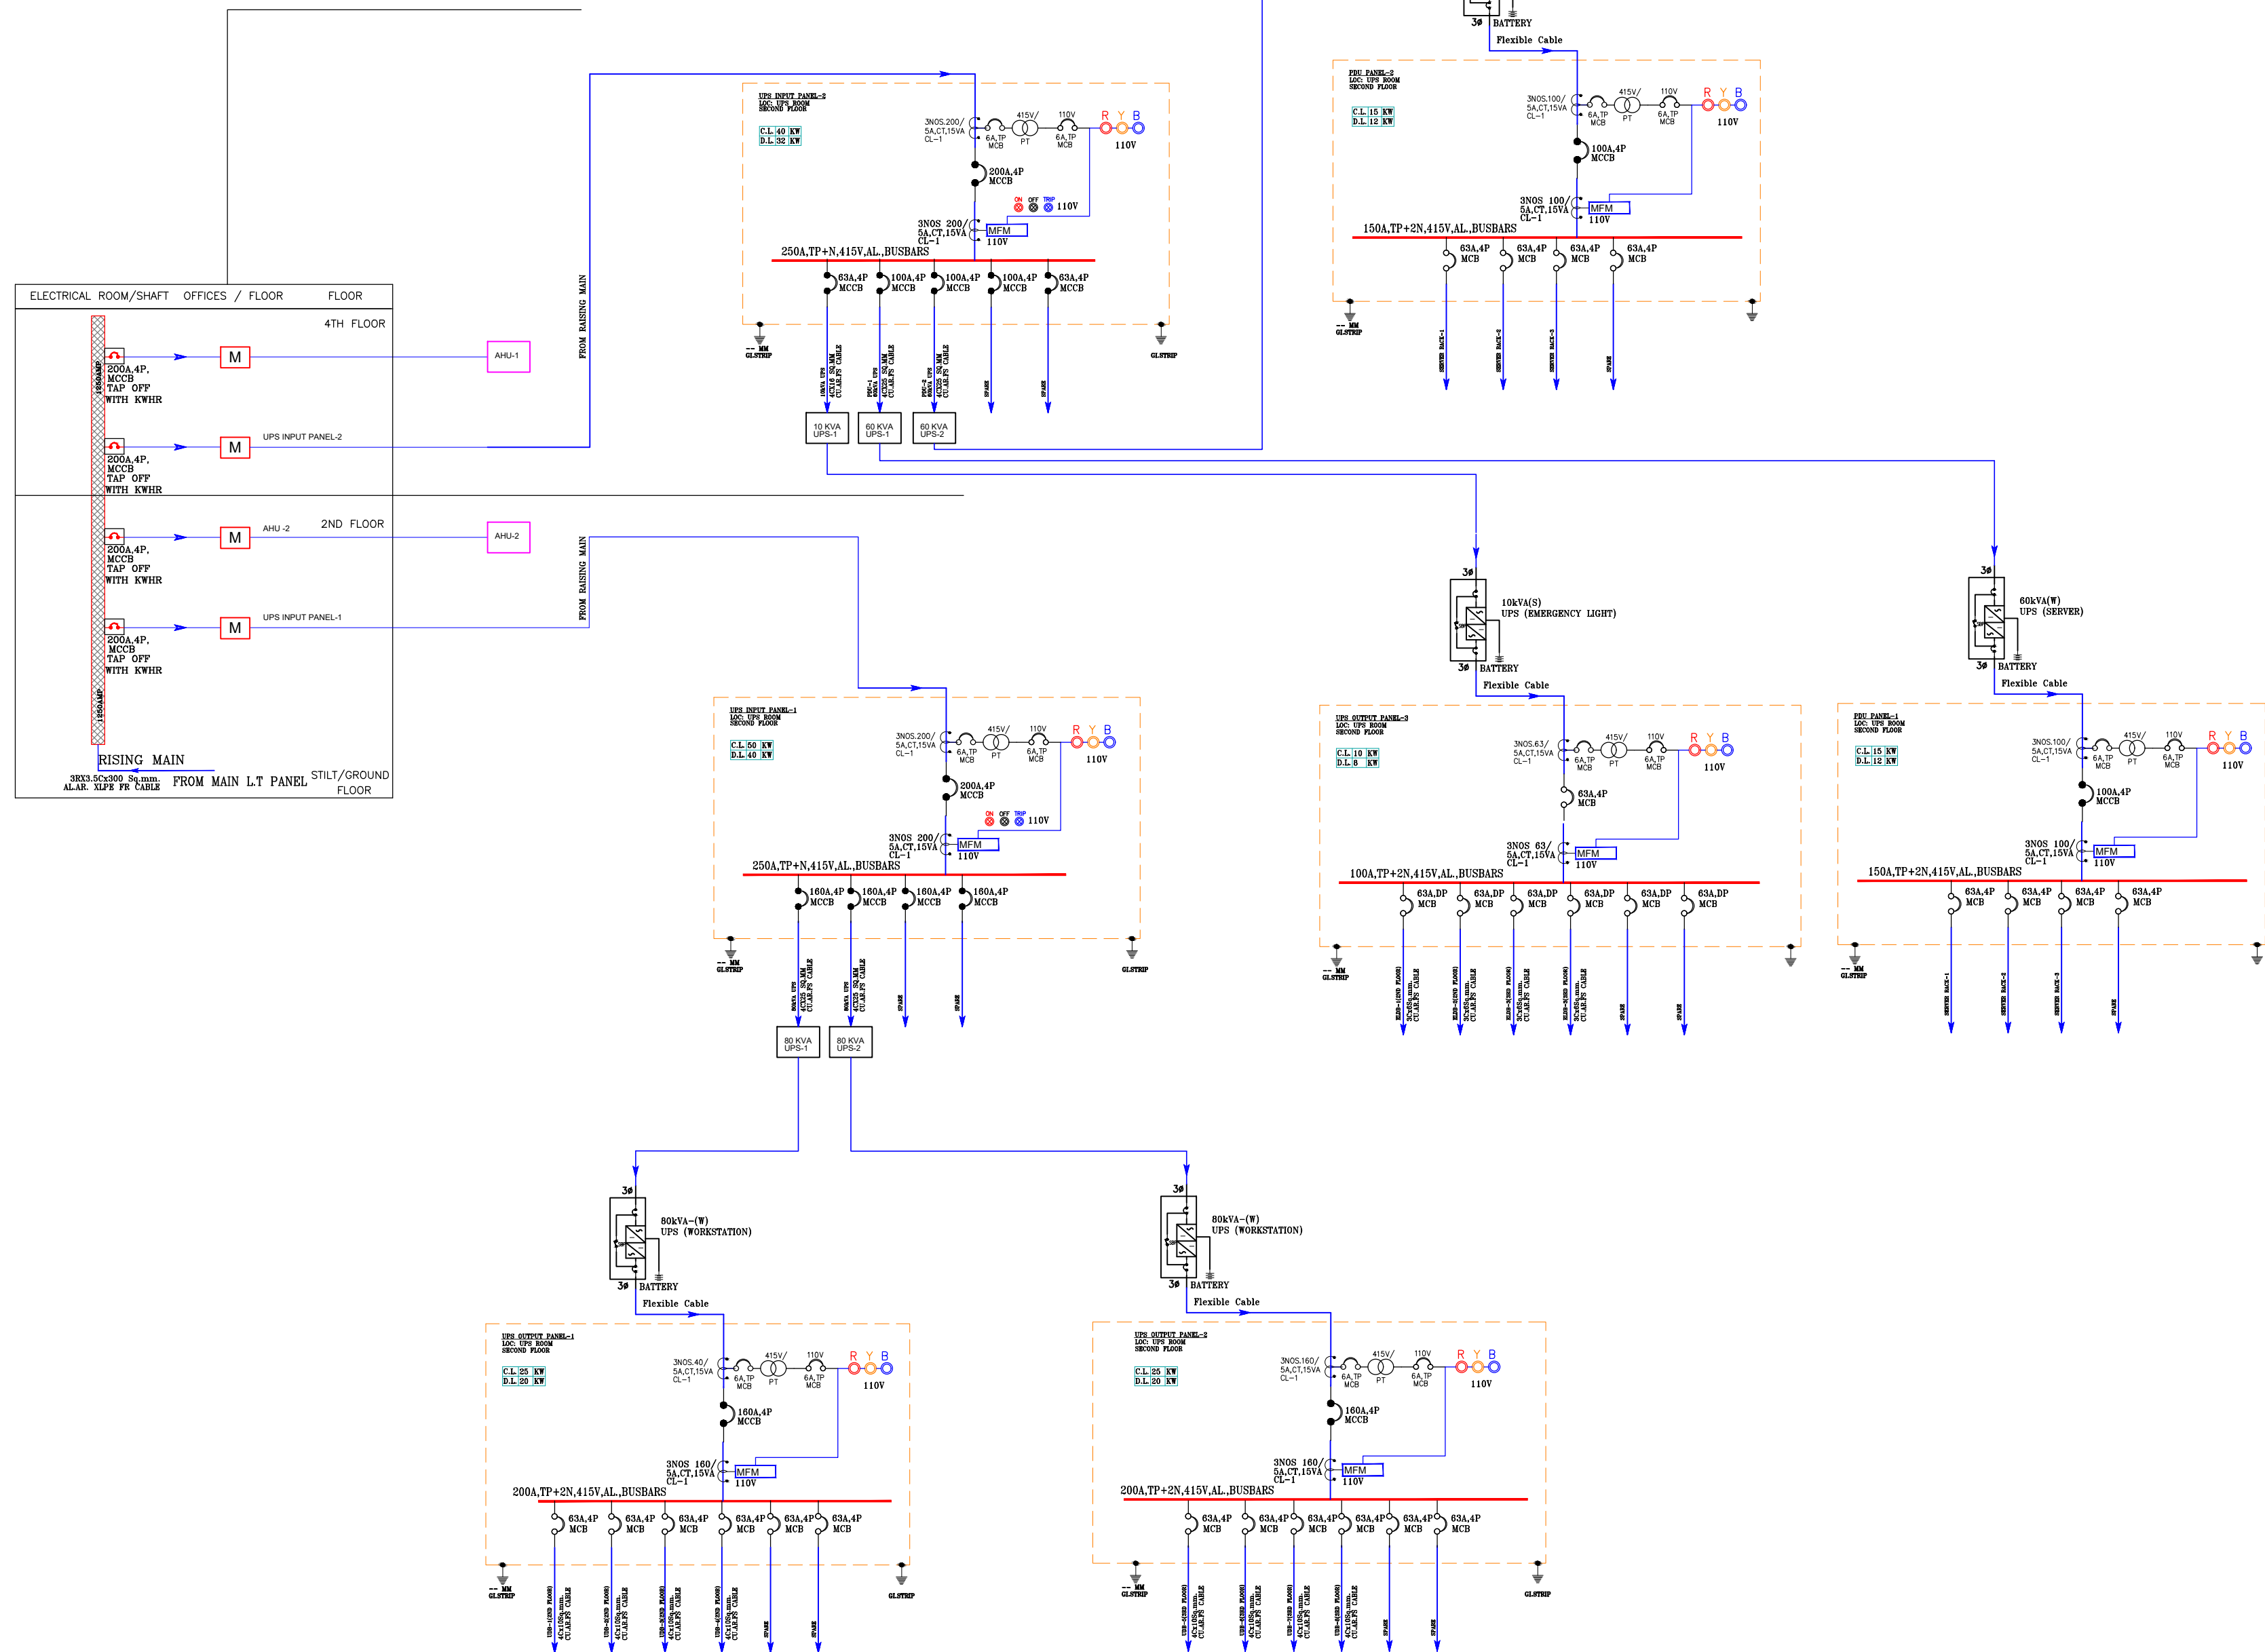

NO.	SYMBOL	DESCRIPTION
01		INSTANT MICRO PROCESSOR BASED OVER CURRENT EARTH FAULT & SHORT CIRCUIT RELEASE
02		DIFFERENTIAL PROTECTION RELAY
03		STAND BY EARTH FAULT RELAY
04		RESTRICTED EARTH FAULT RELAY
05		OVER VOLTAGE & UNDER VOLTAGE RELAY
06		MASTER TRIP RELAY
07		AIR CIRCUIT BREAKER
08		TRANSFORMER
09		AUTO CHANGE OVER SWITCH
10		DIRECT ON LINE STARTER
11		DIGITAL MULTI-FUNCTION METER
12		GENERATOR SET
13		MOULDED CASE CIRCUIT BREAKER
14		DIGITAL MULTI-FUNCTION METER WITH PULSE PORT
15		CLASS-1 METERING CTS
16		CAPACITOR BANK
17		LOW TENSION POTENTIAL TRANSFORMER FOR METERING
18		MINIATURE CIRCUIT BREAKER
19		R - PHASE INDICATION LAMP
20		Y - PHASE INDICATION LAMP
21		B - PHASE INDICATION LAMP
22		VACUUM CIRCUIT BREAKER
23		DCS SET PANEL CONTROLLER
24		ON - INDICATION LAMP
25		OFF - INDICATION LAMP
26		TRIP - INDICATION LAMP
27		STAR DELTA STARTER
28		TP CONTACTOR
29		VACUUM CIRCUIT BREAKER

TENDER DRAWING

MEP CONSULTANT



MCK MEP Consultants
8-1, 78, Akashdeep Marg, DLF Phase 2,
Sector 26, Gurugram, Haryana 122002
Email-mckconsultingengineers@gmail.com
mckneprojects@gmail.com

Drawing Name :

SINGLE LINE DIAGRAM

Drawing By: VK

Scale : NTS

Checked By: PK

Client Name :

Date :

29-12-2023

Revision No :

R0




Drawing Status :

F.I.O.

Tender


G.F.C.

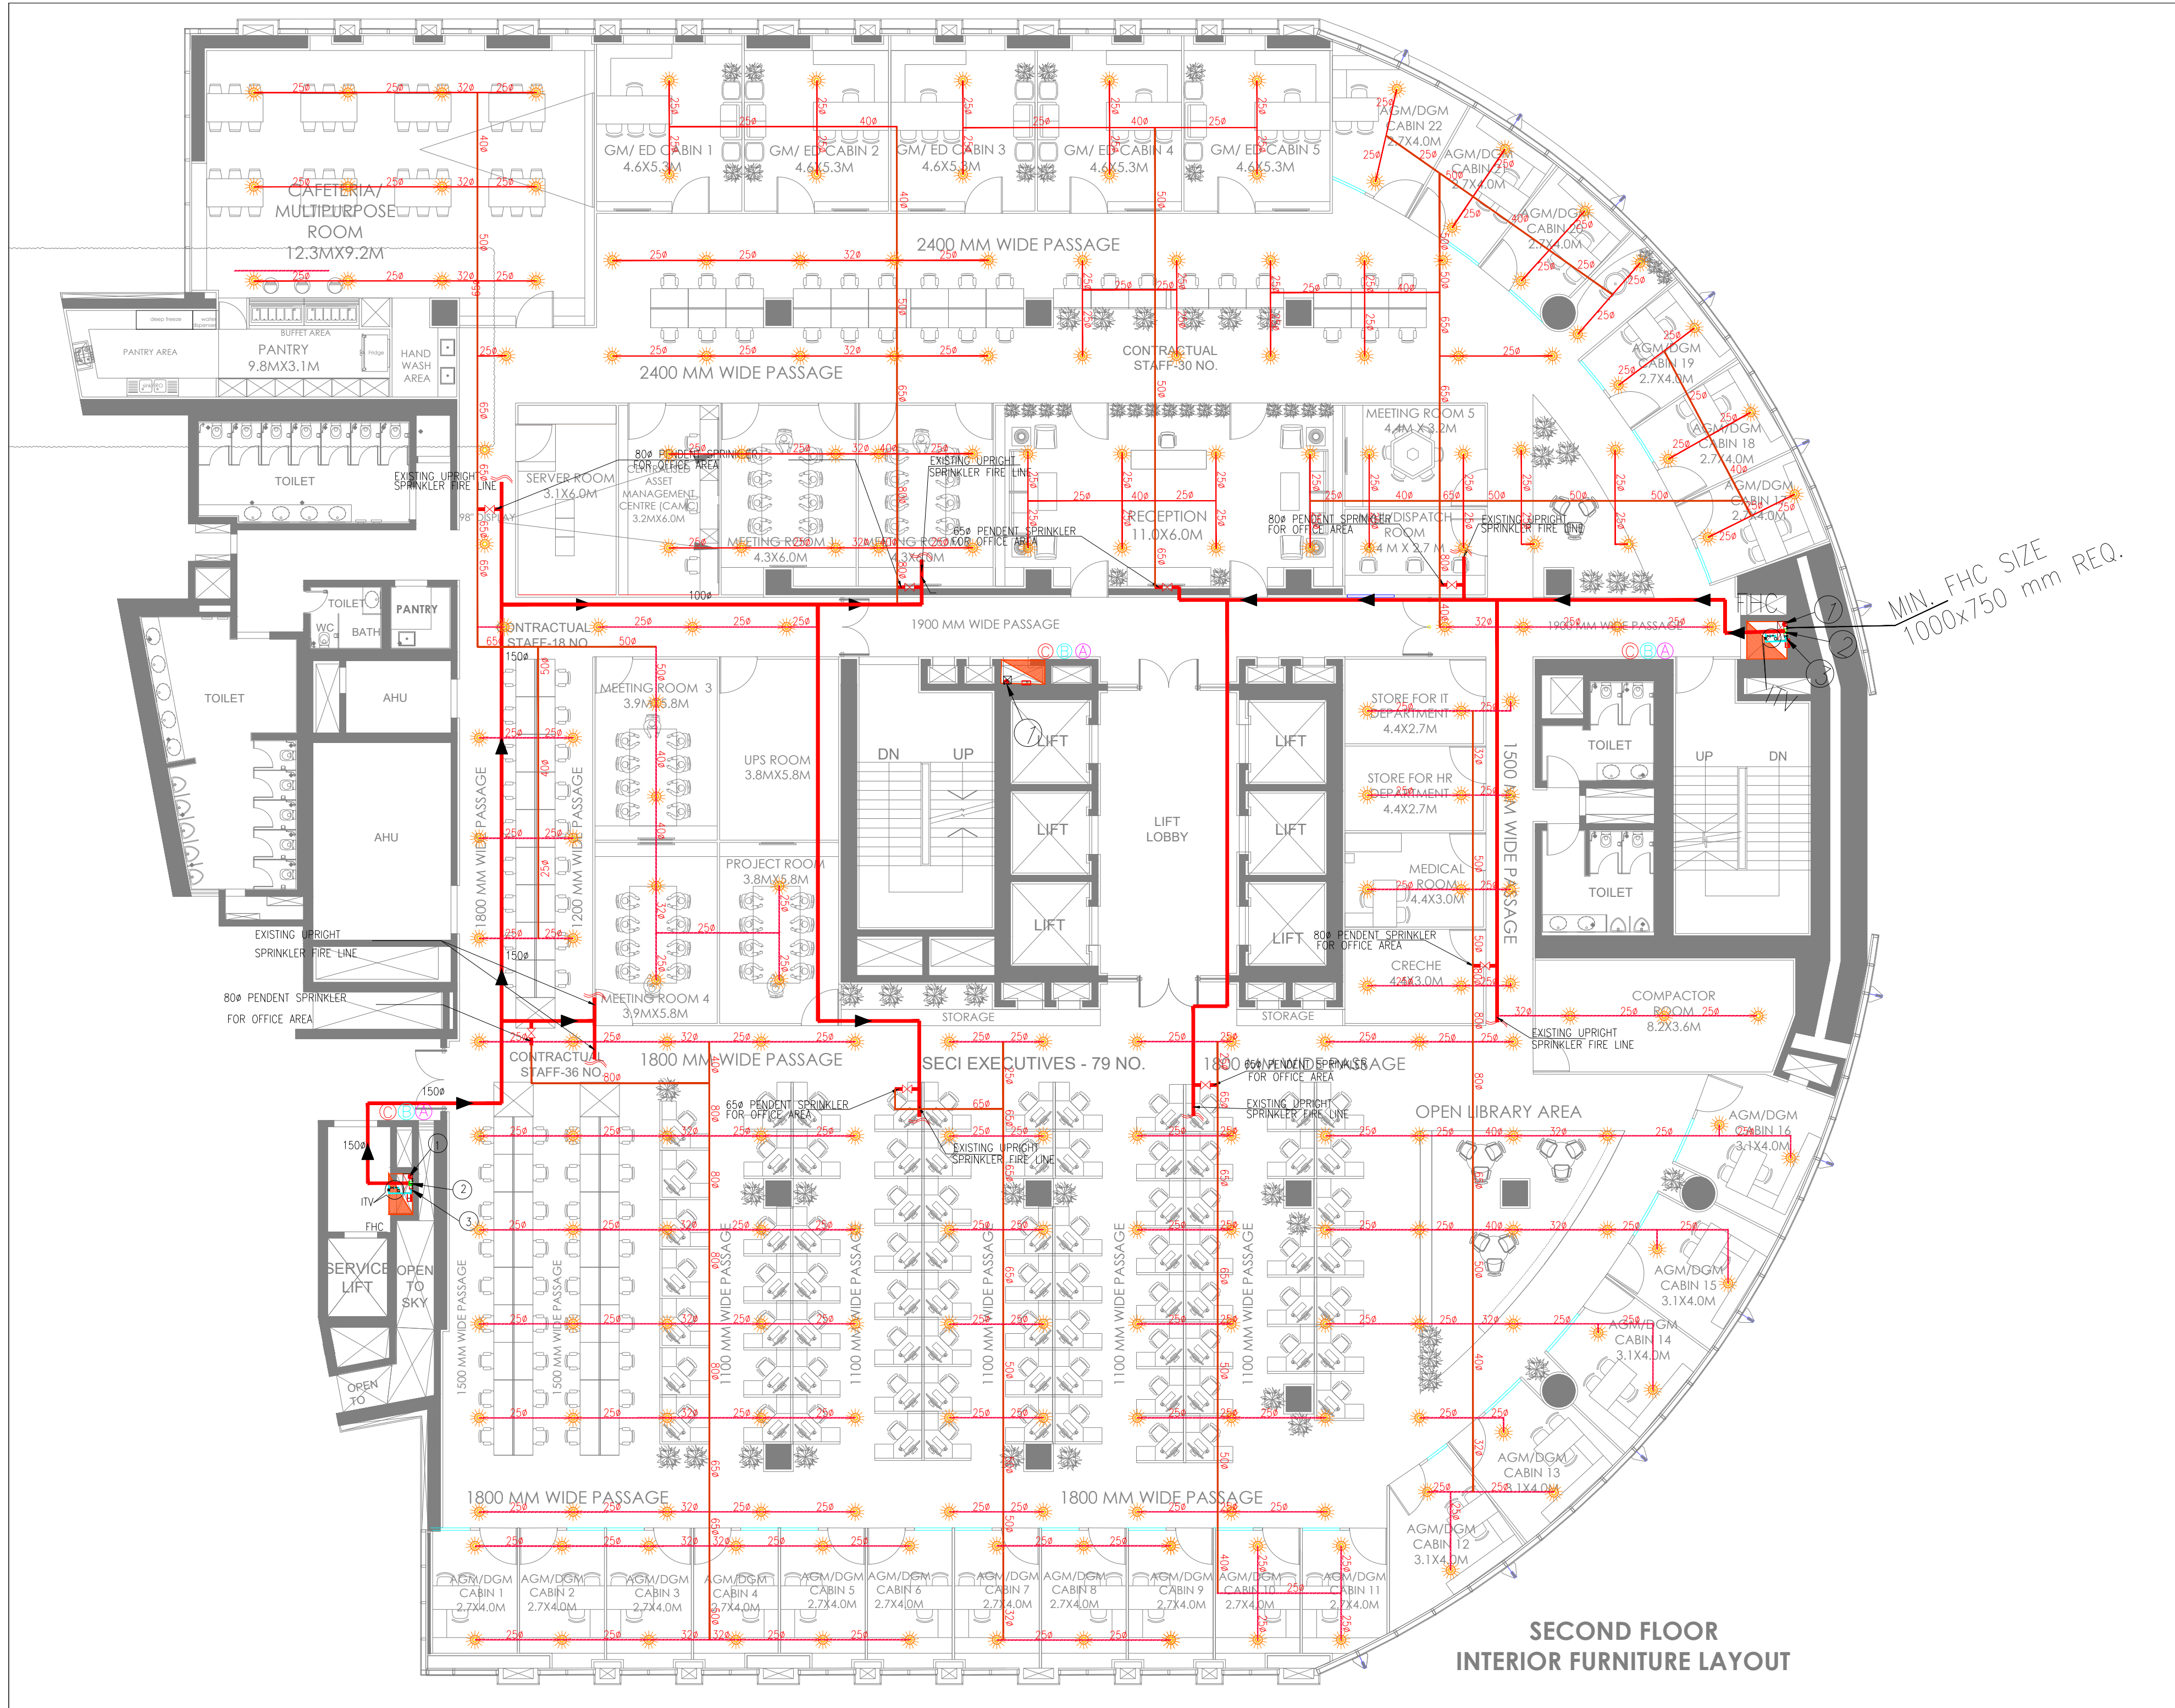

TENDER DRAWING




SN	FIRE FIGHTING LEGEND:-
A	1500 HYDRANT PIPE
B	800 DRAIN PIPE
C	1500 SPRINKLER PIPE
	PENDENT SPRINKLER
FHC	FIRE HOSE CABINET
	BALL / BUTTERFLY VALVE
	FLOW SWITCH

NO. OF SPRINKLER	DIA OF PIPE
1-2	25Ø
3	32Ø
4-5	40Ø
6-10	50Ø
11-20	65Ø
21-40	80Ø
41-100	100Ø
101-ABOVE	150Ø

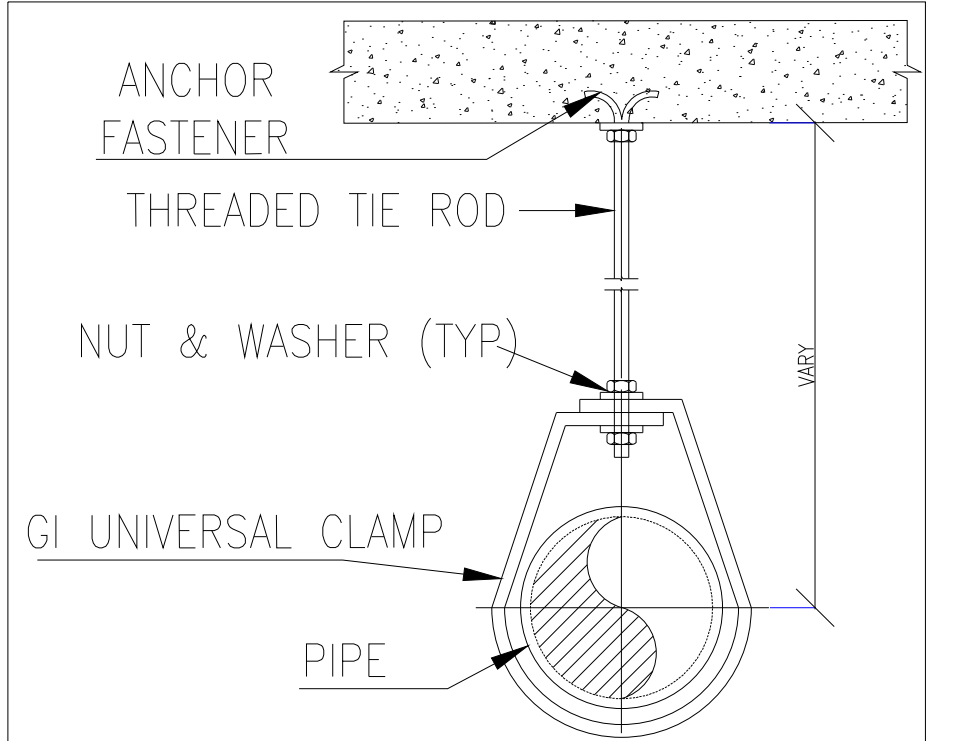

PIPE SUPPORT SPACING DETAILS			
Sl.No.	PIPE DIA. (mm)	HANGER ROD DIA. (mm)	SPACING BETWEEN SUPPORTS (mm)
1	Ø25	Ø8	2000
2	Ø32 TO Ø50	Ø8	2400
3	Ø65	Ø10	2400
4	Ø80	Ø10	2700

TYPICAL INSTALLATION OF SPRINKLER				
Sl.No.	PIPE DIA. (mm)	ISA (mm)	ANCHOR (mm)	U-BOLT (mm)
5	Ø100	40X40X5	M10	Ø10
6	Ø125 TO Ø150	40X40X5	M10	Ø10
7	Ø200 TO Ø300	40X40X5	M12	Ø12

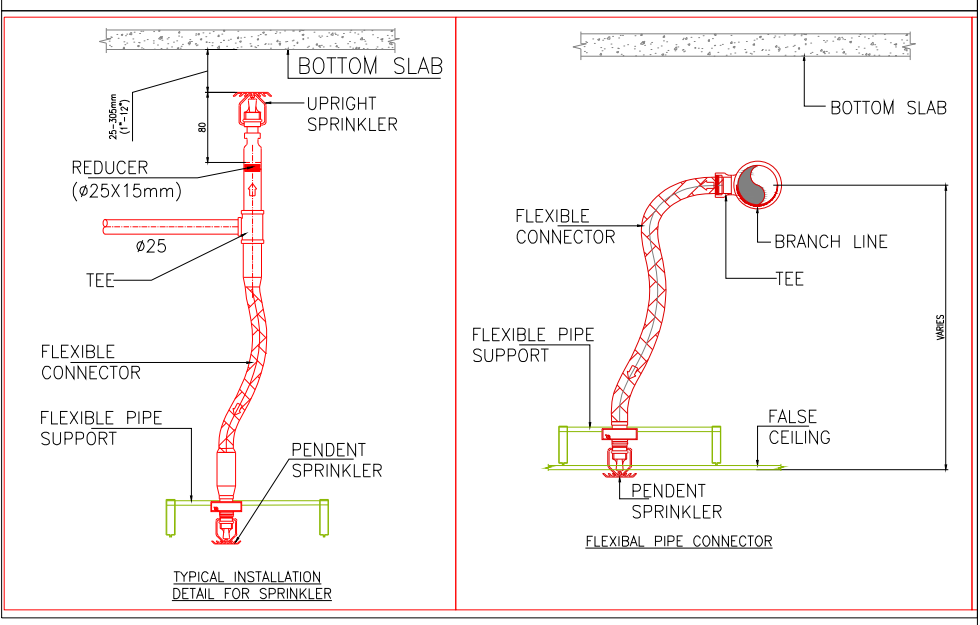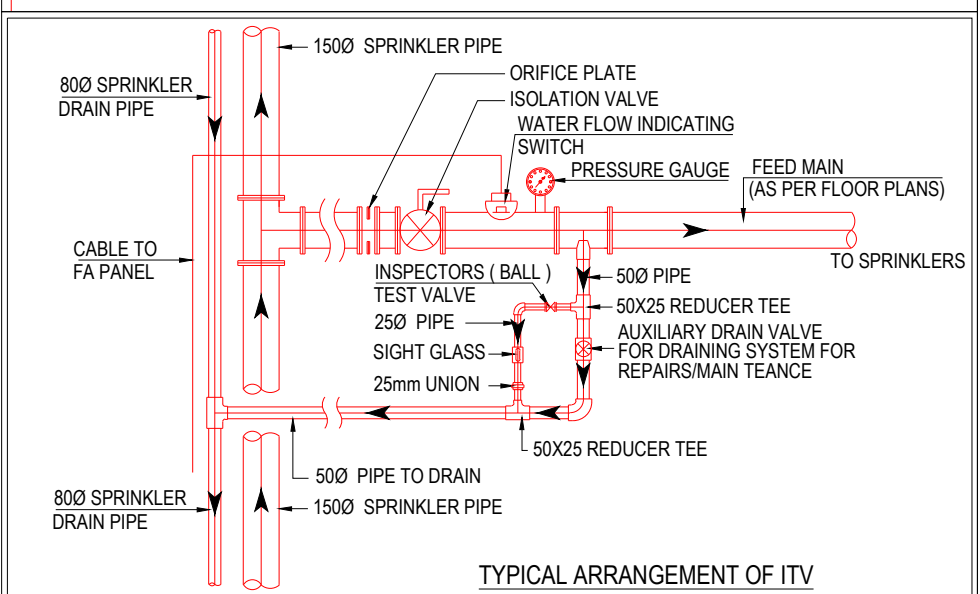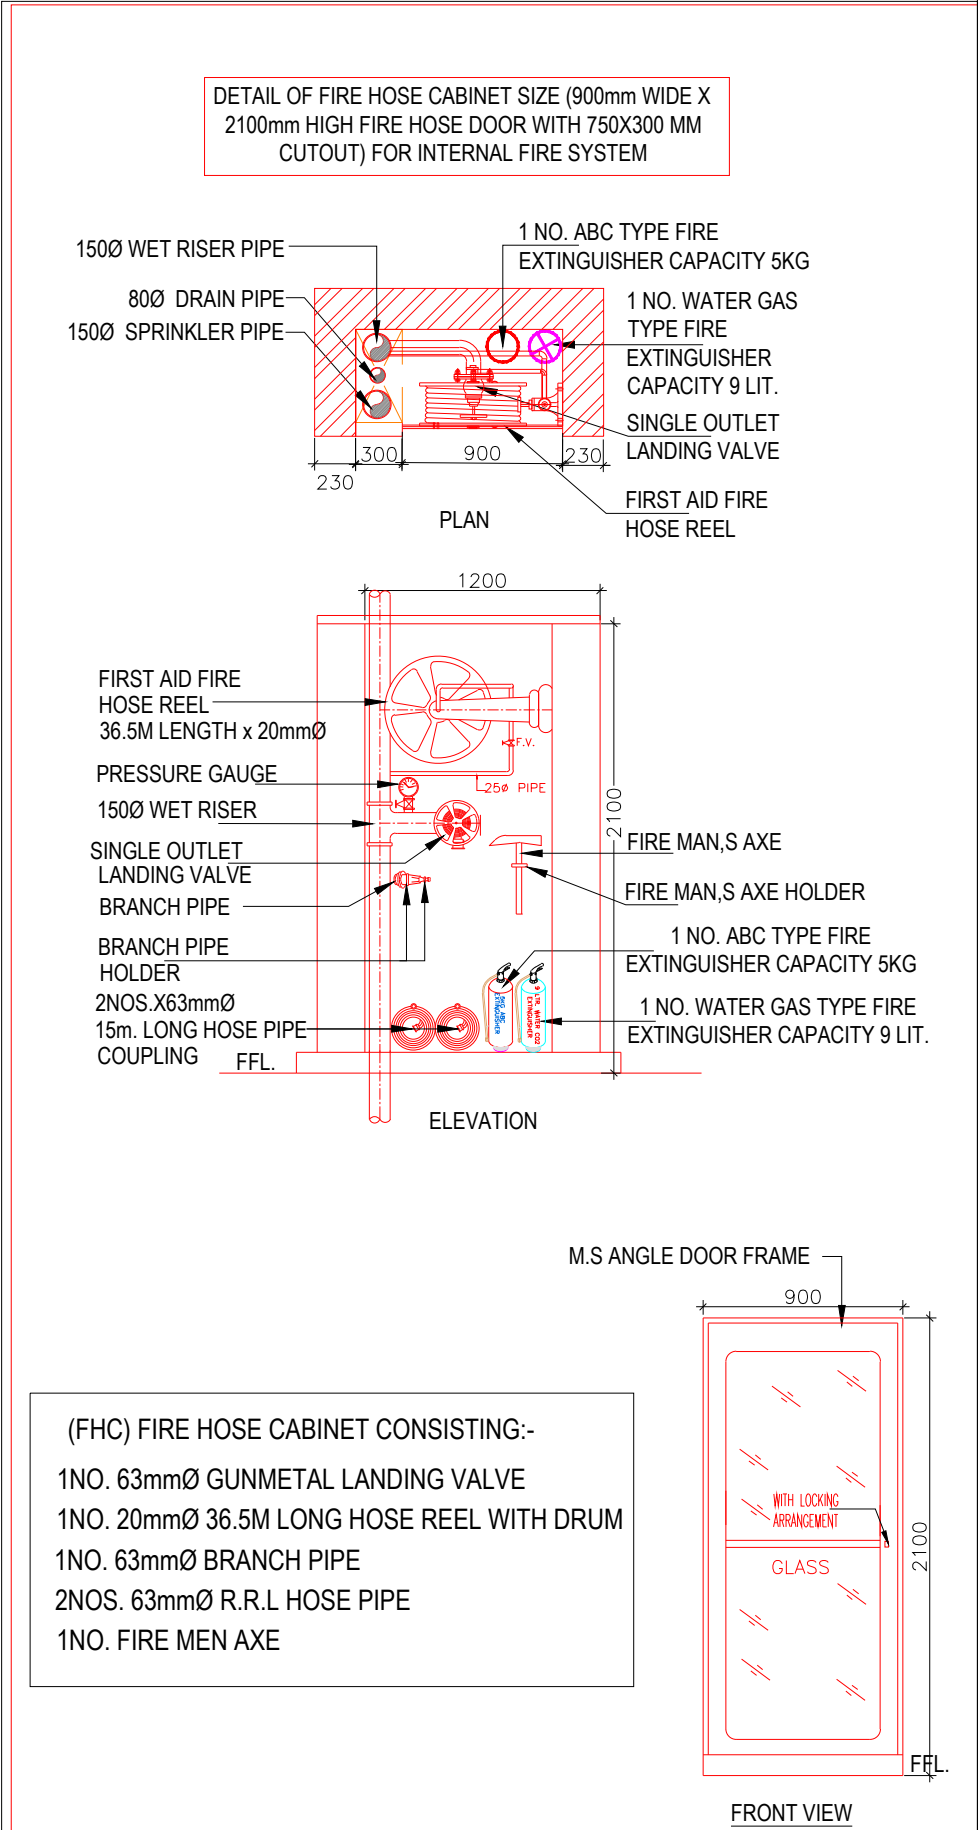


CLIENT:
SOLAR ENERGY CORPORATION OF INDIA (SECI)

PROJECT:
ARCHITECTURAL AND ENGINEERING CONSULTANCY SERVICES FOR INTERIOR WORKS AT TOWER-F 2nd & 3rd FLOOR ,NAUROJI NAGAR, NBCC DELHI

ARCHITECT:
ATKV CONSULTANTS PVT. LTD.
E-107 (LOWER GROUND FLOOR) G.K.-II
NEW DELHI-110048
PH.NO. 40536580,29214906 TEL. FAX: 29214906

MCK MEP Consultants
B-1, 78, Alakhnesh Marg, DLF Phase 2,
Sector 25, Gurugram, Haryana 122002
Email: mck.mepconsultants@gmail.com
Office: mckprojects@gmail.com

STAGE	TENDER DRAWING
DRAWING TITLE	SECOND FLOOR PLAN FIRE FIGHTING LAYOUT
Designed	D.V.
Checked	A.D.
Approved	P.K.
Scale	Date
NTS@A1	16.02.2025
Drawing No.	Rev. No.
	R-0
	ORIENTATION:
	MCK-SECI-FF-SF-01

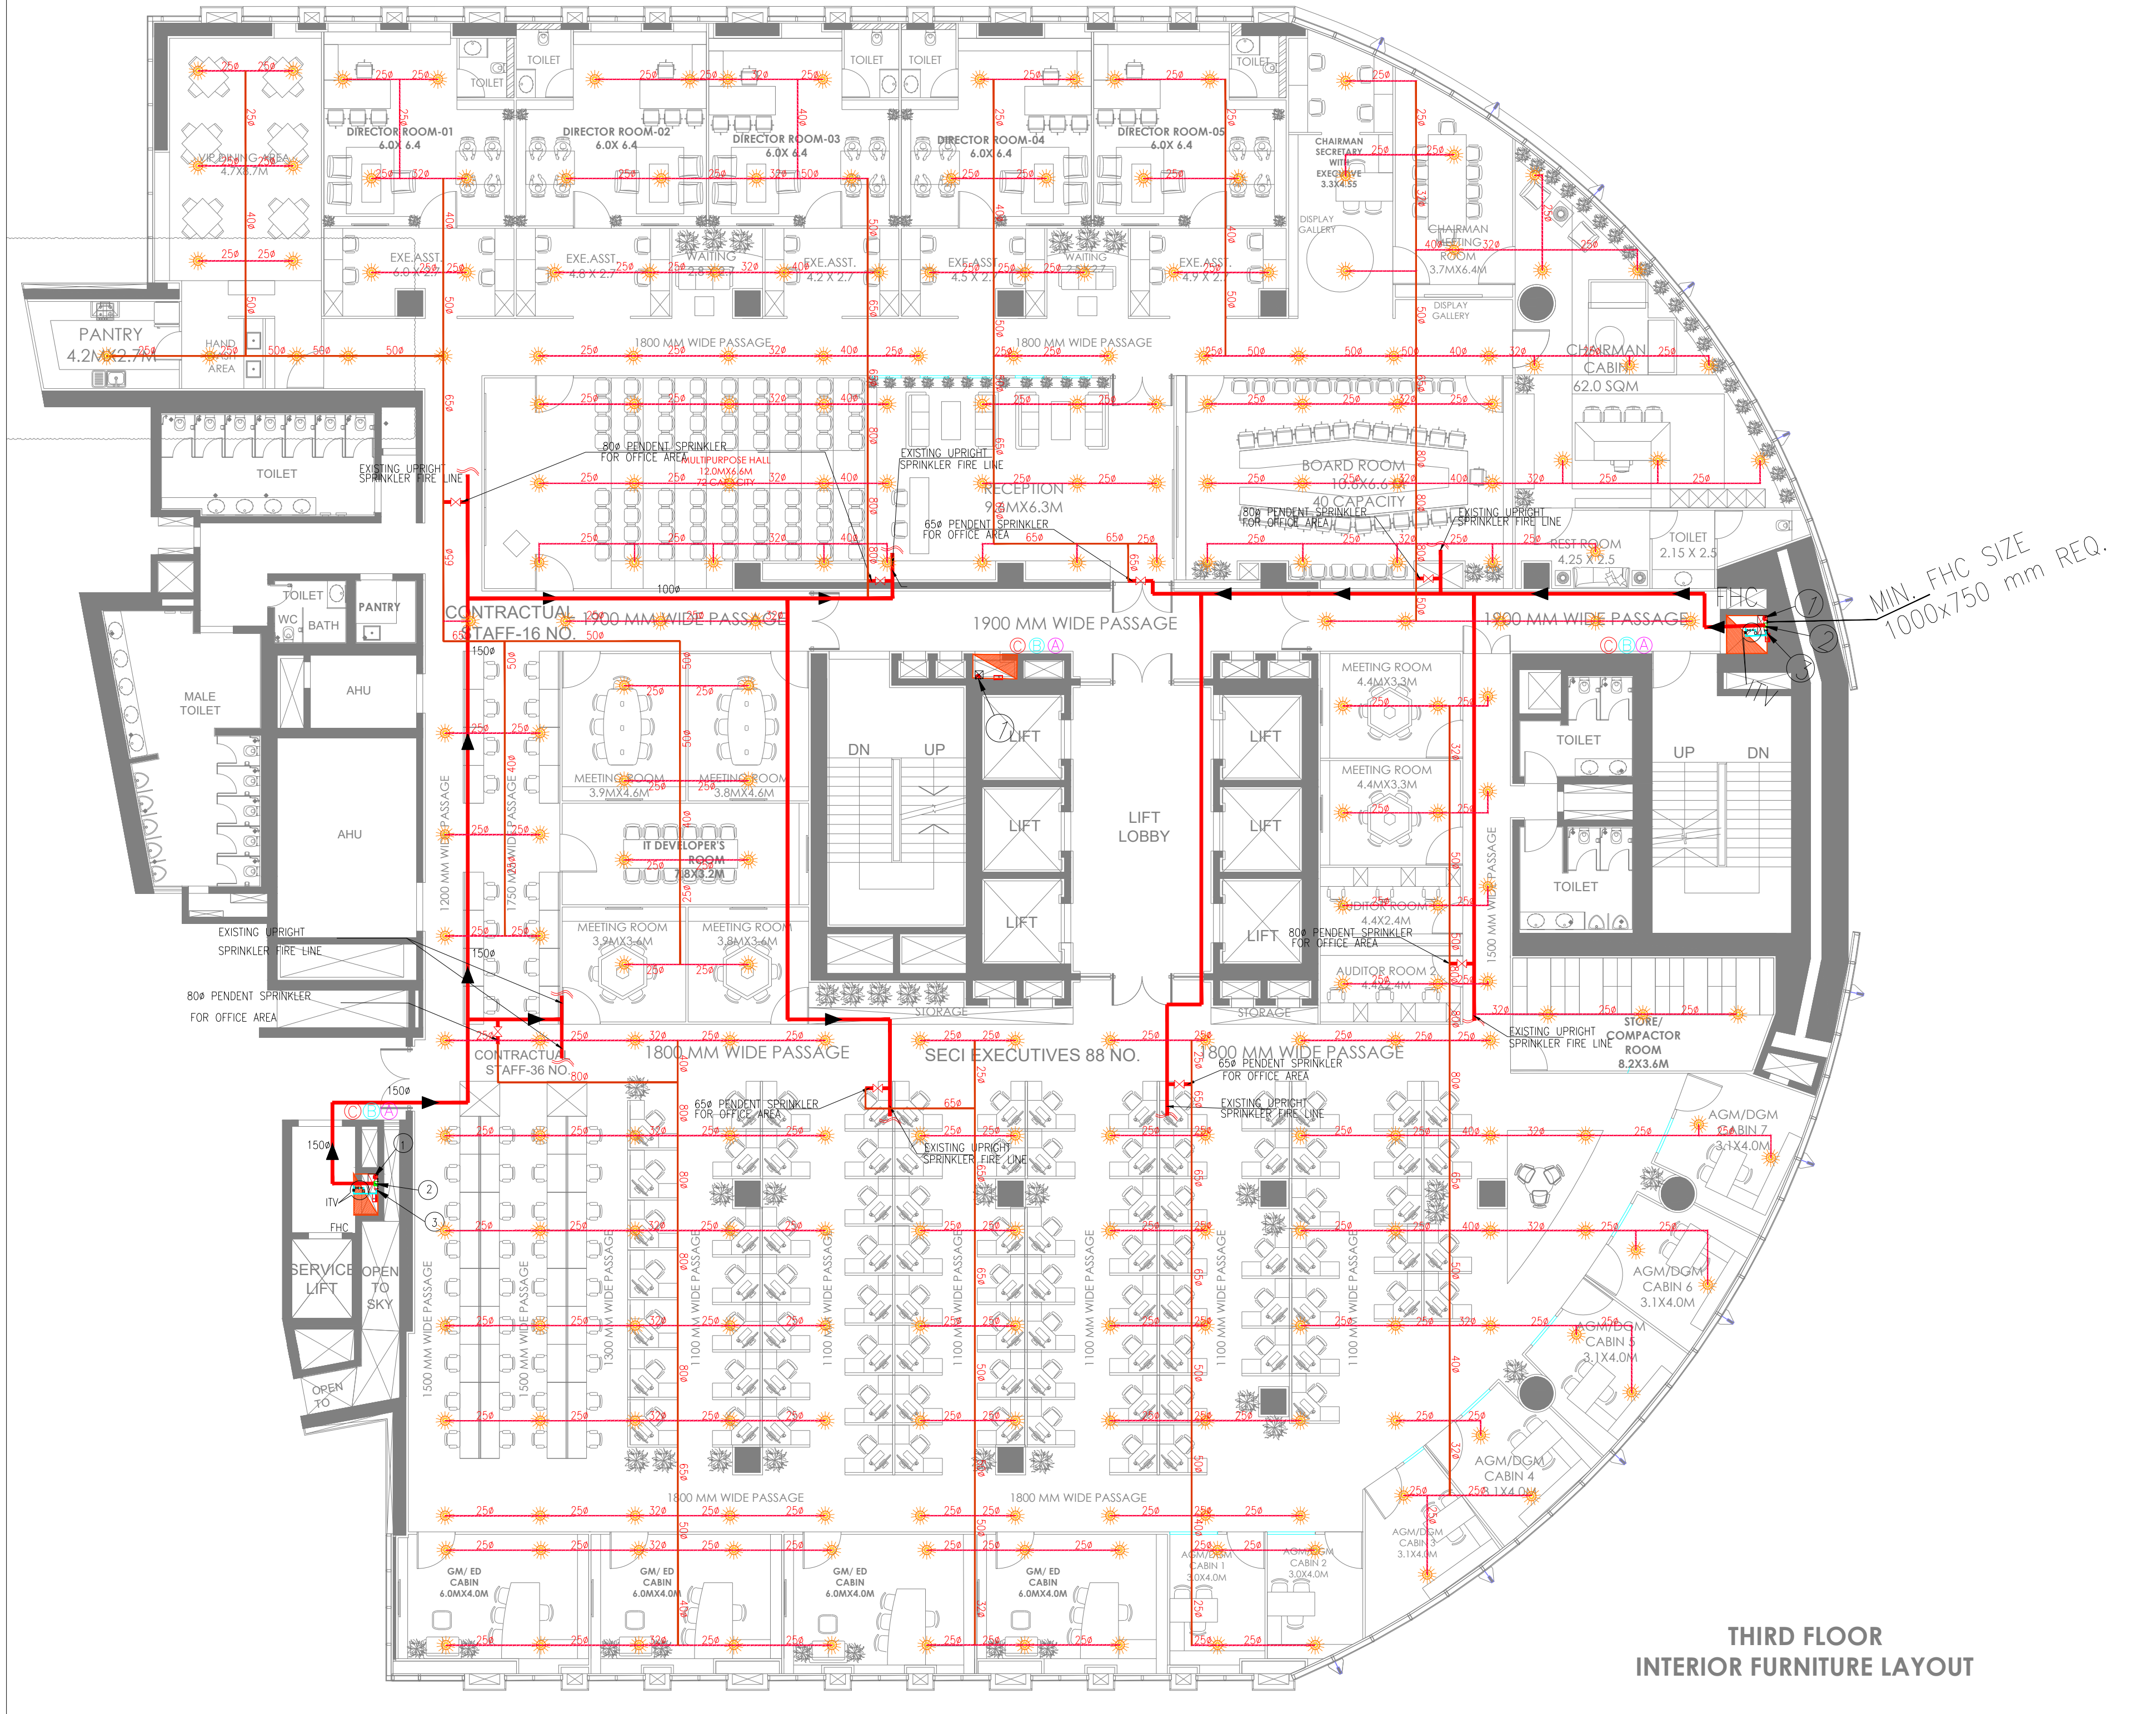


THIRD FLOOR
INTERIOR FURNITURE LAYOUT






TENDER DRAWING

SN	FIRE FIGHTING LEGEND:-
A	1500 HYDRANT PIPE
B	800 DRAIN PIPE
C	1500 SPRINKLER PIPE
	PENDENT SPRINKLER
FHC	FIRE HOSE CABINET
	BALL / BUTTERFLY VALVE
	FLOW SWITCH

NO. OF SPRINKLER	DIA OF PIPE
1-2	250
3	320
4-5	400
6-10	500
11-20	650
21-40	800
41-100	1000
101-ABOVE	1500

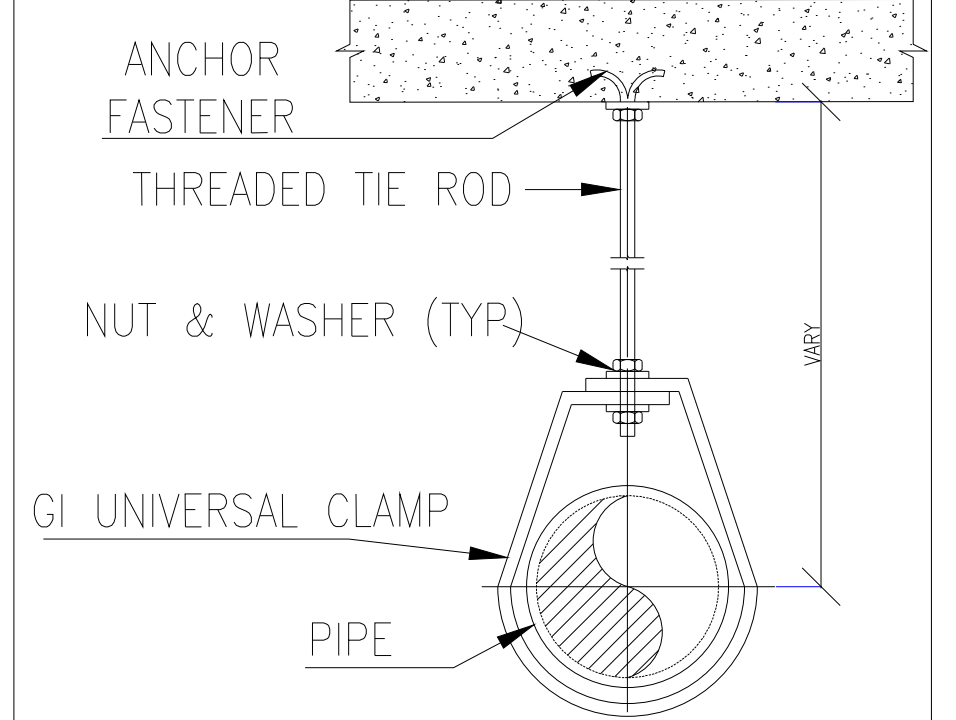

PIPE SUPPORT SPACING DETAILS			
Sl.No.	PIPE DIA. (mm)	HANGER ROD DIA. (mm)	SPACING BETWEEN SUPPORTS (mm)
1	25	8	2000
2	32 TO 50	8	2400
3	65	10	2400
4	80	10	2700

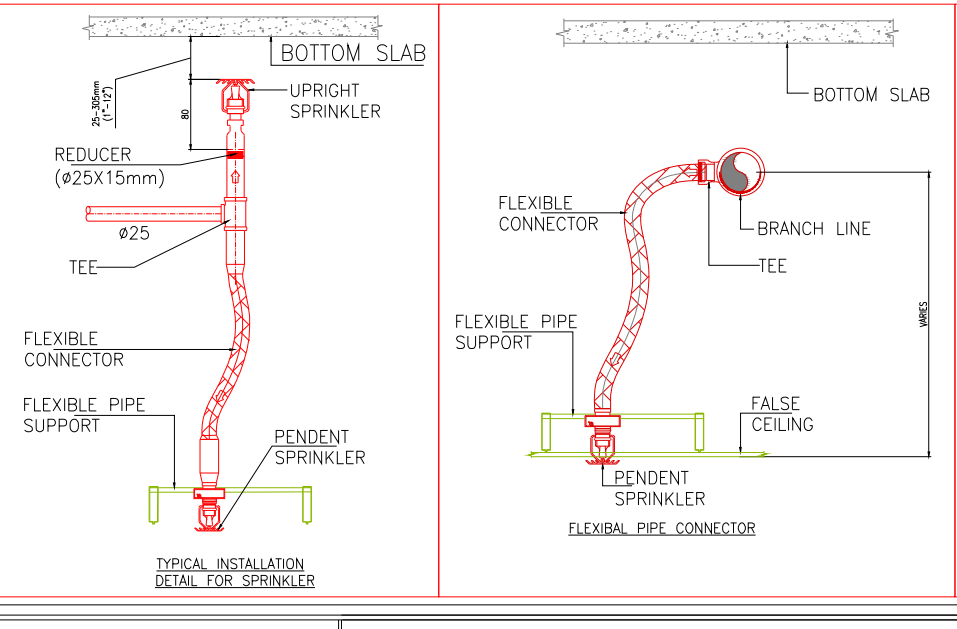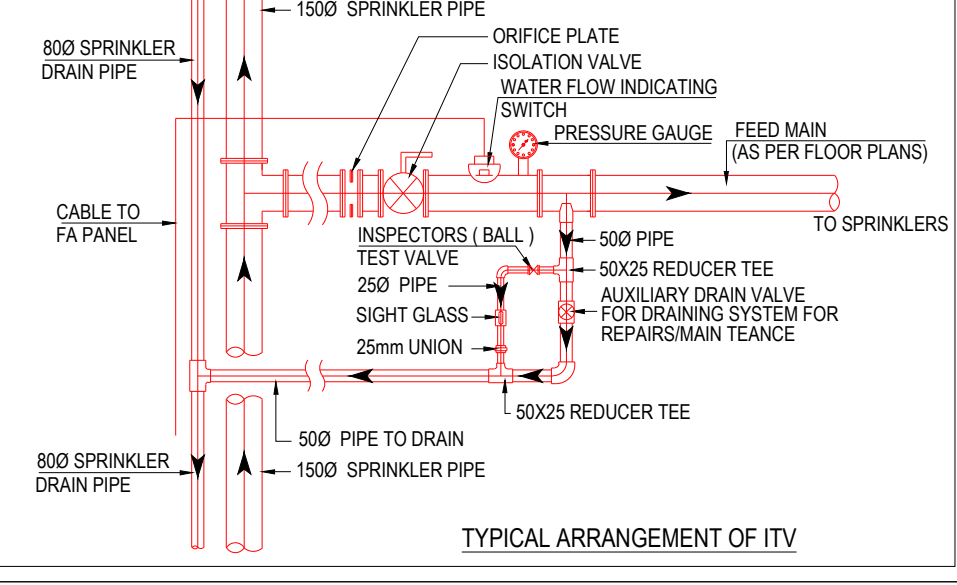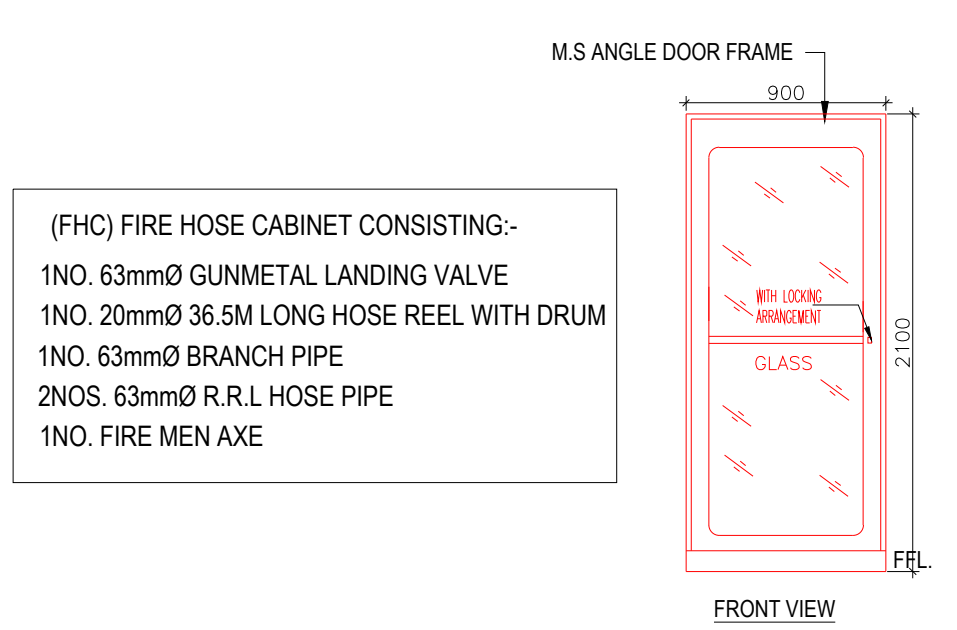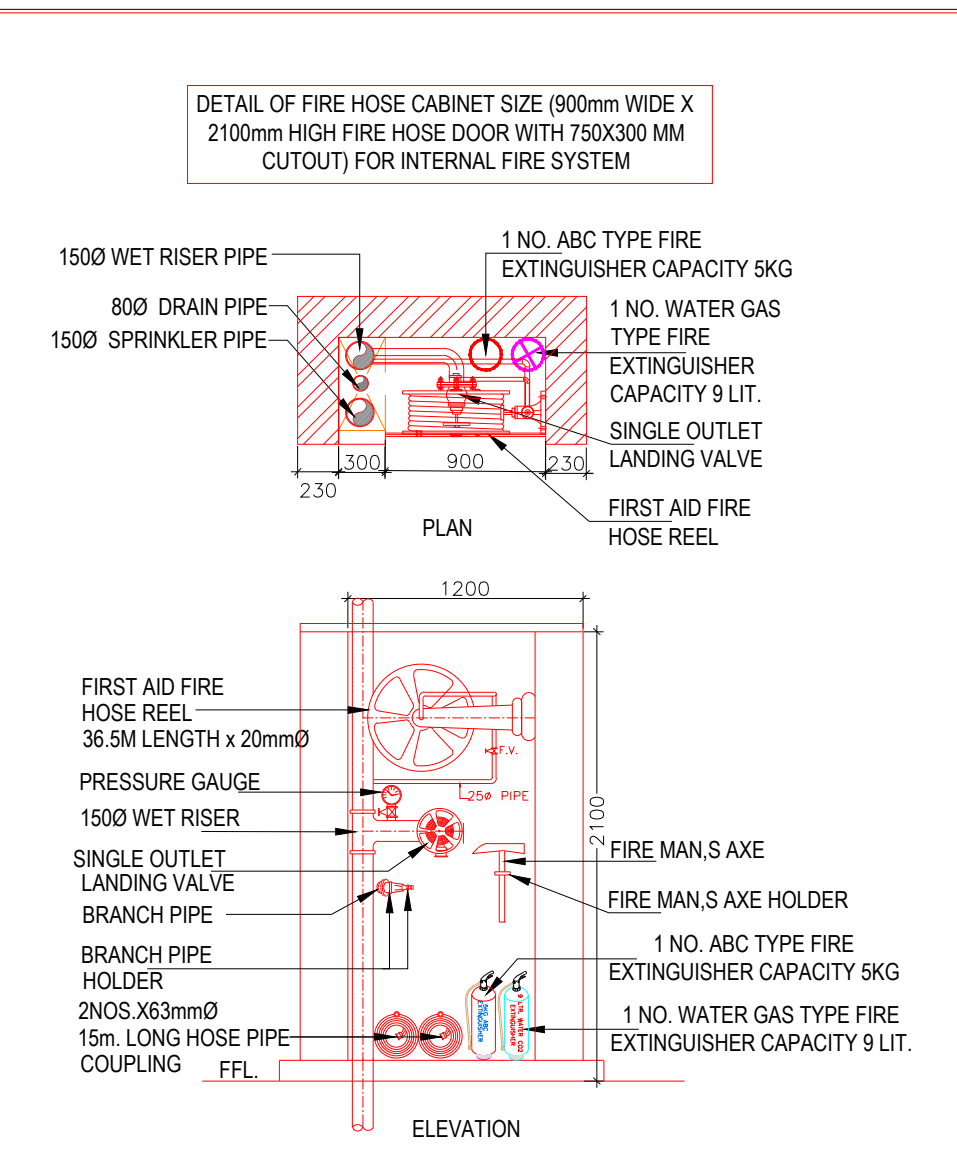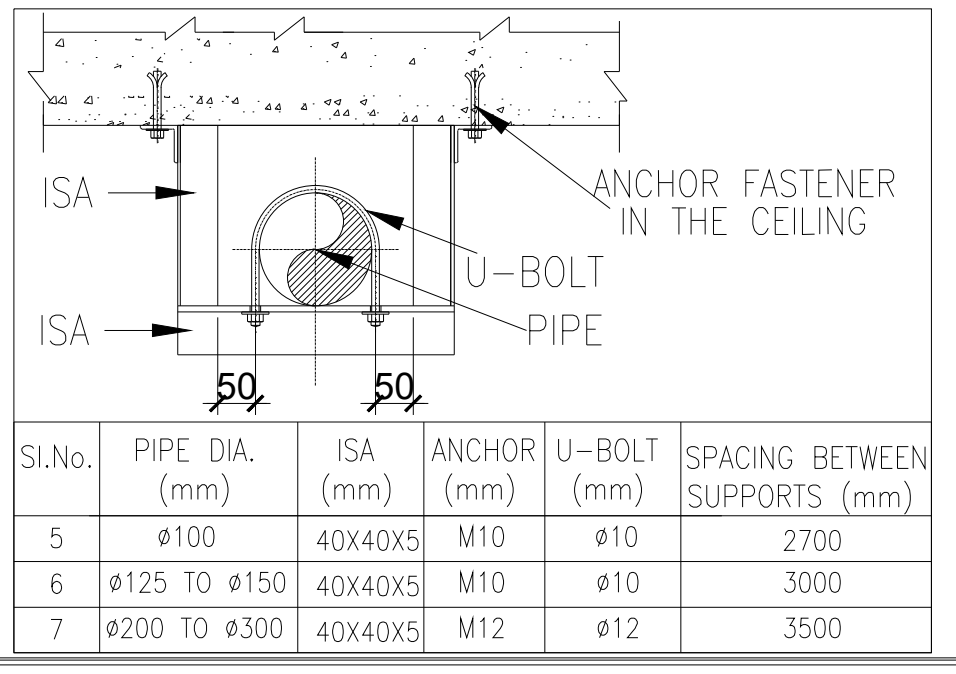

CLIENT:
SOLAR ENERGY CORPORATION OF INDIA (SECI)

PROJECT:
ARCHITECTURAL AND ENGINEERING CONSULTANCY SERVICES FOR INTERIOR WORKS AT TOWER-F 2nd & 3rd FLOOR ,NAUROJI NAGAR, NBCC DELHI

ARCHITECT:
ATKV CONSULTANTS PVT. LTD.
E-107 (LOWER GROUND FLOOR) G.K.-II
NEW DELHI-110048
PH.NO. 40536580,29214906 TEL. FAX: 29214906

MCK

MCK MEP Consultants

8-1, 78, Alakhnagar Marg, DLF Phase 2, Sector 25, Gurugram, Haryana 122002

Email: mck.mep.consultants@gmail.com

Office: mckproject@gmail.com

STAGE

TENDER DRAWING

DRAWING TITLE

THIRD FLOOR PLAN
FIRE FIGHTING LAYOUT

Designed

D.V.

Checked

A.D.

Approved

P.K.

Scale

NTS@A1

Date

16.02.2025


Rev. No.

R-0

Drawing No.

MCK-SECI-FF-TF-02

ORIENTATION:

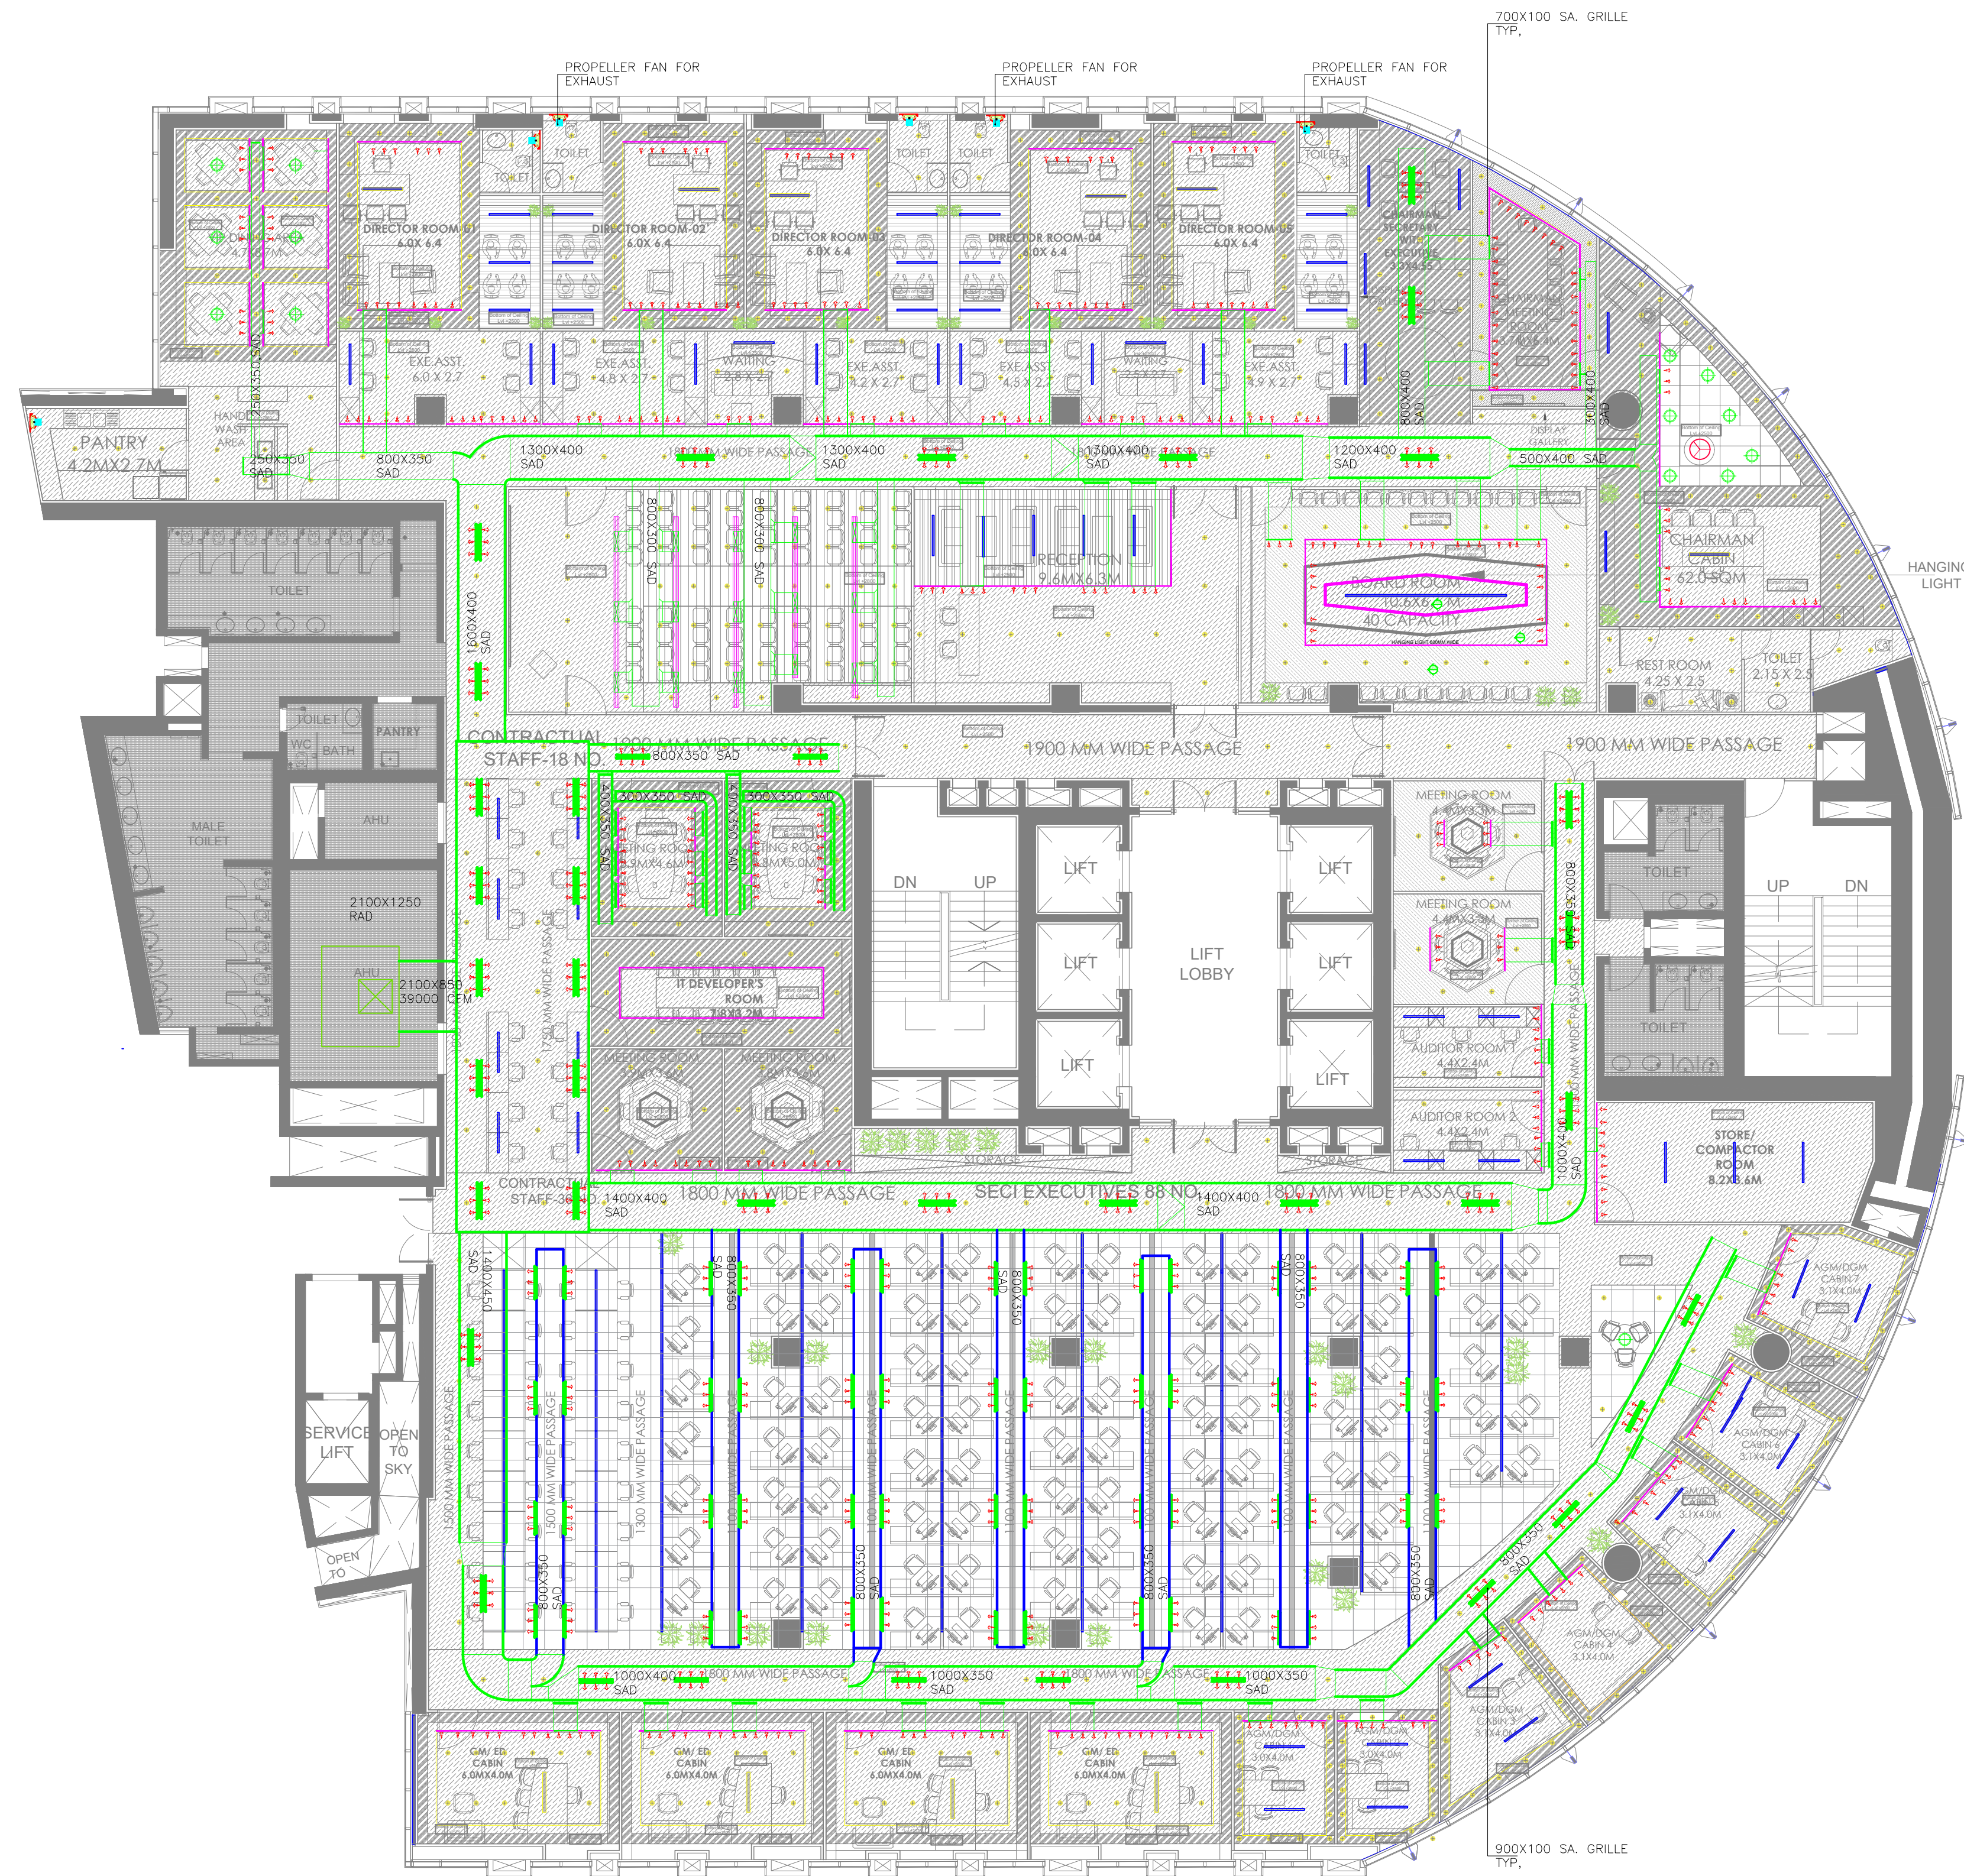

SN	HVAC LEGEND:-
	AC SUPPLY AIR
	AC RETURN AIR
	AC GRILLE
	AC SITE GRILLE

TENDER DRAWING

CLIENT:
SOLAR ENERGY CORPORATION OF INDIA (SECI)

PROJECT:
ARCHITECTURAL AND ENGINEERING CONSULTANCY SERVICES FOR INTERIOR WORKS AT TOWER-F 2nd & 3rd FLOOR ,NAUROJI NAGAR, NBCC DELHI

ARCHITECT:
ATKV CONSULTANTS PVT. LTD.
E-107 (LOWER GROUND FLOOR) G.K.-II
NEW DELHI-110048
PH.NO. 40536580,29214906 TEL. FAX: 29214906

		MCK MEP Consultants B-1, 78, Akashnesh Marg, DLF Phase 2, Sector 25, Gurugram, Haryana 122002, Email-mck_consultingengineers@gmail.com office.mckprojects@gmail.com	
STAGE		DESIGN DEVELOPMENT	
DRAWING TITLE		THIRD FLOOR PLAN HVAC LAYOUT	
Designed	D.V.	Checked	A.D.
Scale	NTS@A1	Date	15.02.2025
Drawing No.	MCK-SECI-HVAC-TF-02		Rev. No. R-0
			ORIENTATION: 



LEGEND	
1.	6AMP OUTLET FOR AC (ABOVE FALSE CEILING)
2.	6 AMP OUTLET WITH ONE SWITCH (2 SETS)
3.	5x6 AMP OUTLET WITH ONE SWITCH FOR TV
4.	16A POWER SOCKET WITH 16A SWITCH FOR PRINTER
5.	16A POWER SOCKET WITH 16A SWITCH
6.	16A POWER SOCKET WITH 16A SWITCH FOR AIR PURIFIER
7.	16A POWER SOCKET WITH 16A SWITCH ROOM HEATER
8.	6A POWER SOCKET FOR GEYSER
9.	1x16A RAW POWER POINT WITH 1x16A SWITCH FOR HAND DRYER
10.	2 NO. 5AMP UNIVERSAL RAW OUTLET 2 NO. 5AMP UNIVERSAL UPS OUTLET 1 USB POWER SOURCE
11.	2 NO. 13AMP UNIVERSAL OUTLET CONTROLLED BY 1 NO. 16AMP SWITCH (UPS)
12.	2 NO. 13AMP UNIVERSAL OUTLET CONTROLLED BY 1 NO. 16AMP SWITCH (RAW POWER)
13.	5 NO. 13AMP UNIVERSAL OUTLET CONTROLLED BY 1 NO. 16AMP SWITCH (RAW POWER)
14.	1x6AMP RAW POWER SOCKET
15.	1x6AMP UPS POWER SOCKET
16.	1x16AMP RAW POWER SOCKET FOR RO
17.	1x16AMP RAW POWER SOCKET FOR REFRIGERATOR

LEGEND:-		
S.NO.	SYMBOL	DESCRIPTION
1.		ONE DATA OUTLET
2.		TWO DATA OUTLET
3.		THREE DATA OUTLET
4.		TWO DATA & TWO VOICE OUTLET
5.		TWO DATA & ONE VOICE OUTLET
6.		ONE DATA & ONE VOICE OUTLET
7.		ONE VOICE OUTLET
8.		DATA OUTLET FOR LCD (CAT-6 CABLE)


TENDER DRAWING

CLIENT:
SOLAR ENERGY CORPORATION OF INDIA (SECI)

PROJECT:
ARCHITECTURAL AND ENGINEERING CONSULTANCY SERVICES FOR INTERIOR WORKS AT TOWER-F 2nd & 3rd FLOOR ,NAUROJI NAGAR, NBCC DELHI

ARCHITECT:
ATKV CONSULTANTS PVT. LTD.
E-107 (LOWER GROUND FLOOR) G.K.-II
NEW DELHI-110048
PH.NO. 40536580,29214906 TEL. FAX: 29214906

		MCK MEP Consultants B-1, 78, Alakhnesh Marg, DLF Phase 2, Sector 25, Gurugram, Haryana 122002 Email-mck_consultingengineers@gmail.com mckneprojects@gmail.com	
STAGE		DESIGN DEVELOPMENT	
DRAWING TITLE		SECOND FLOOR PLAN POWER AND DATA LAYOUT	
Designed	A.D.	Checked	Approved
Scale	Date	Rev. No.	P.K.
1:110@A1	16.02.2025		R-0
Drawing No.	MCK-SECI-EL-SF-01		ORIENTATION:

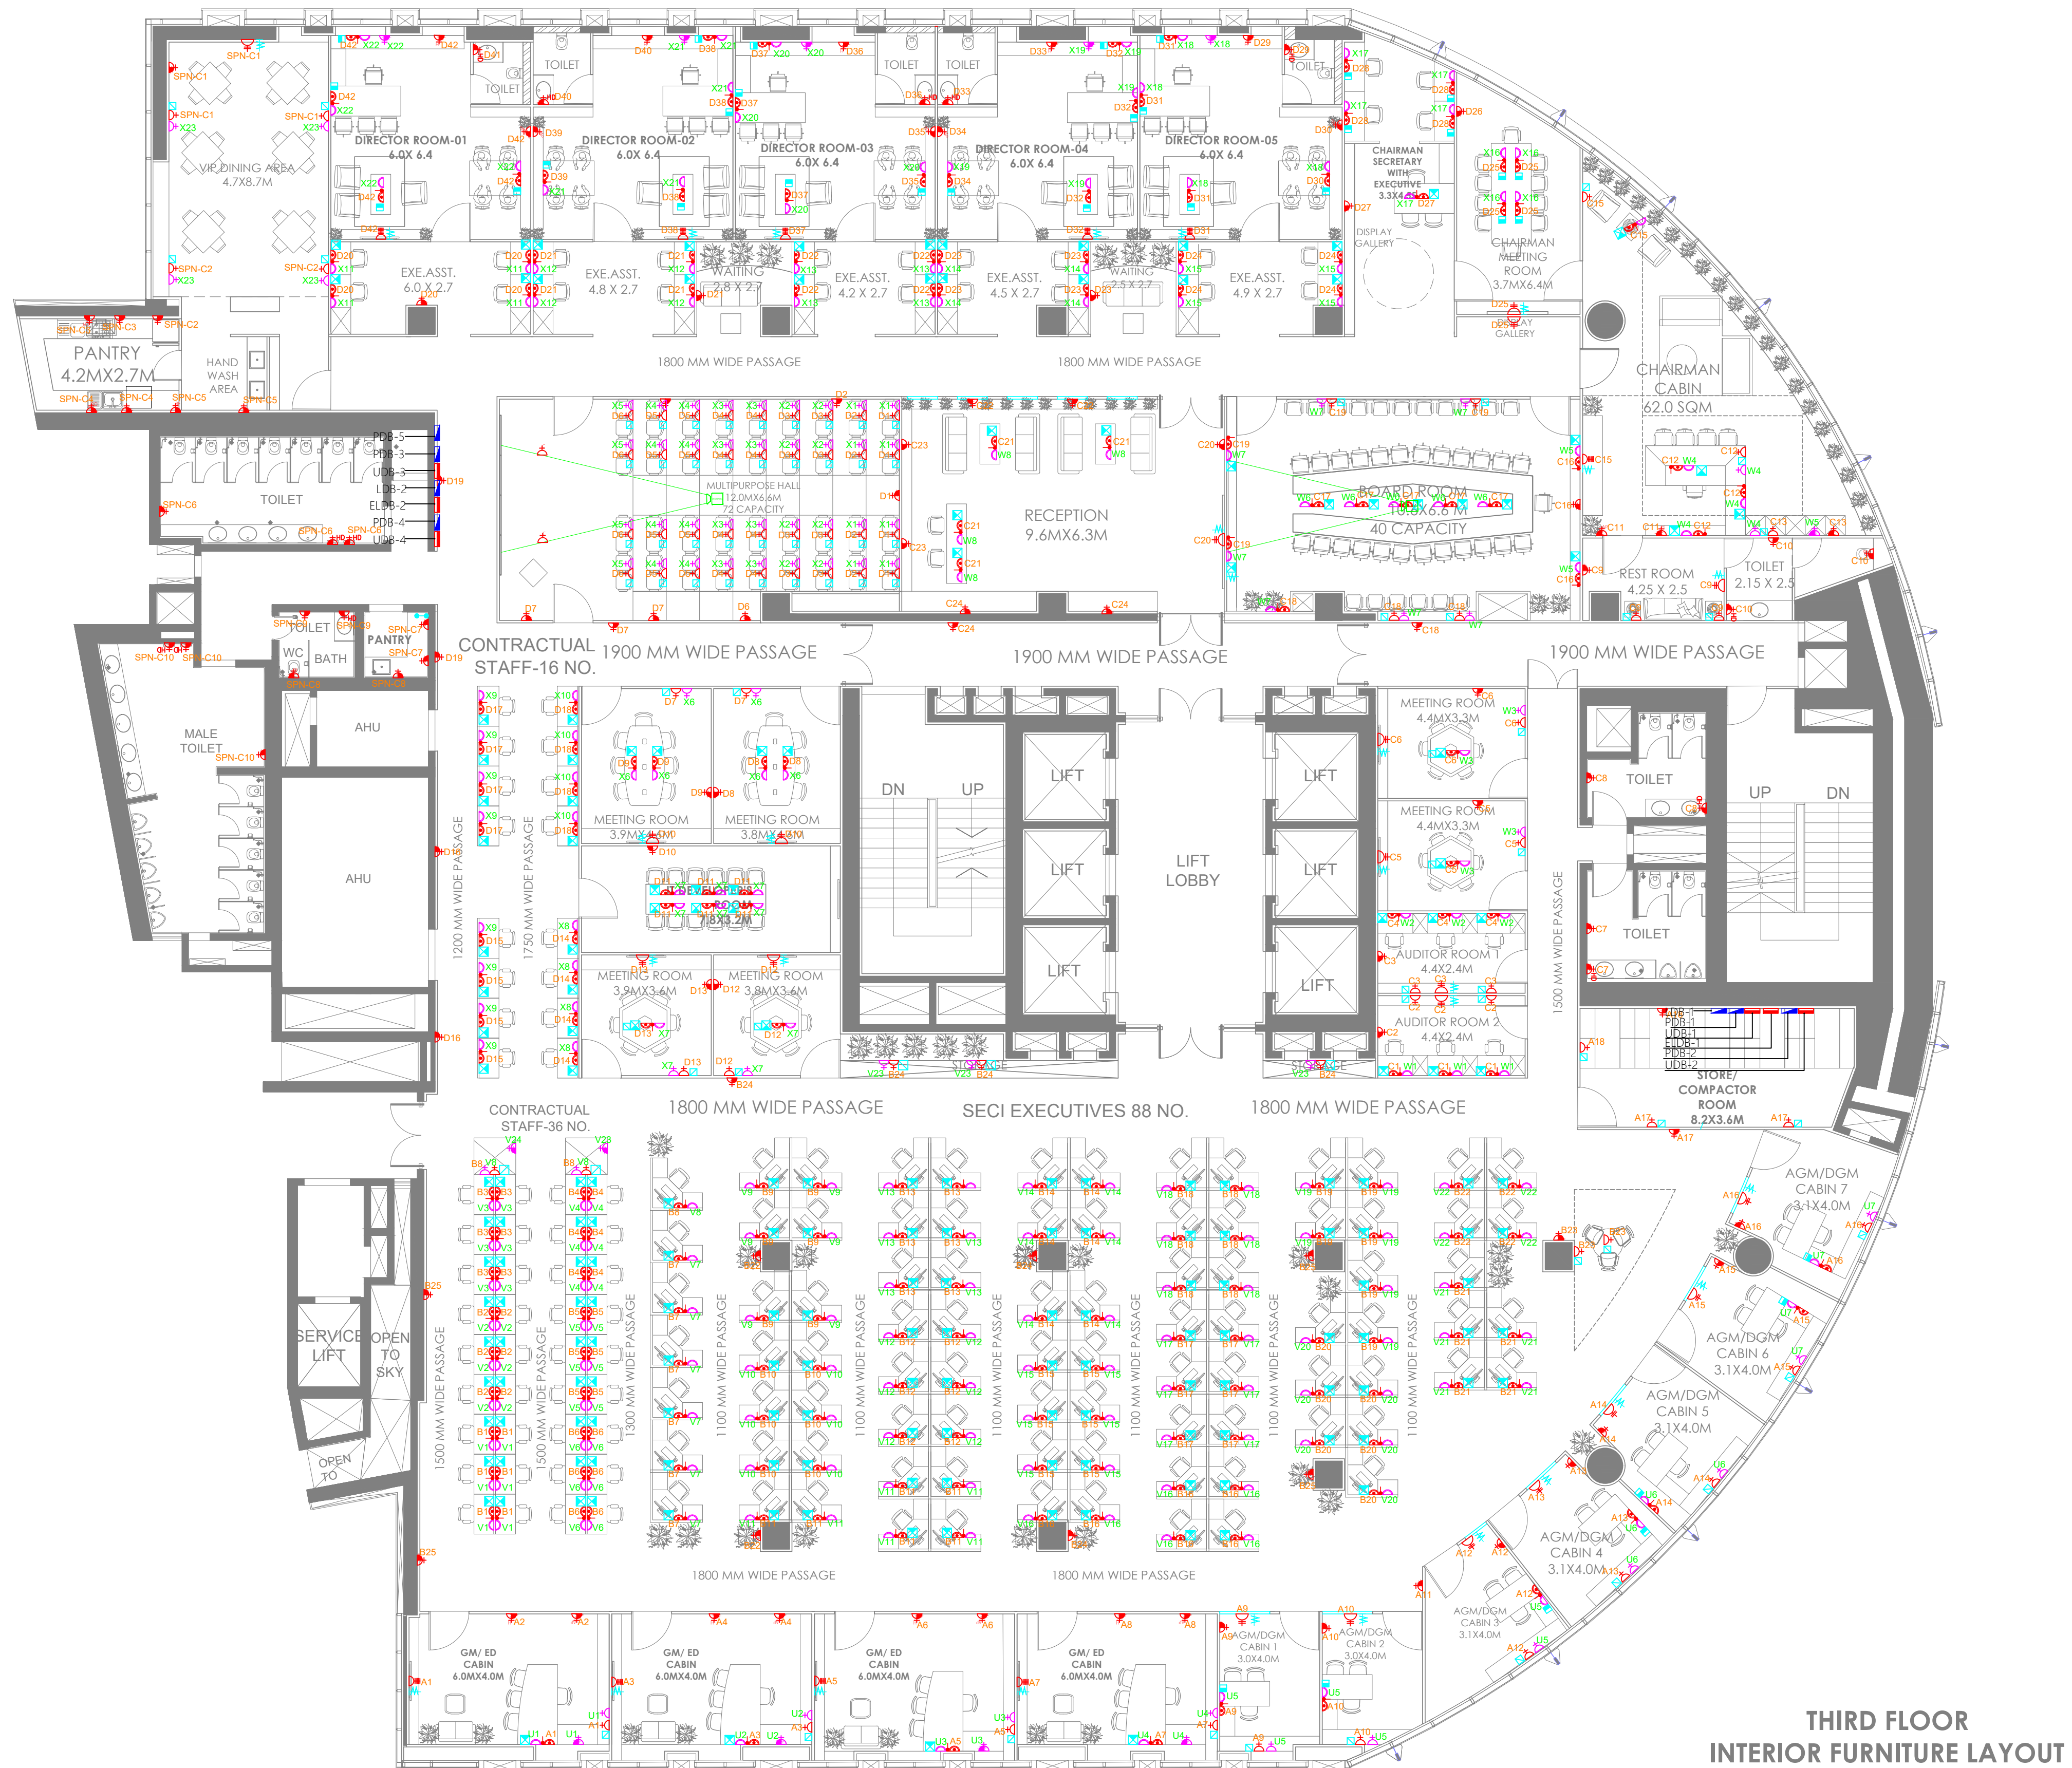

LEGEND	
1.	6AMP OUTLET FOR AC (ABOVE FALSE CEILING)
2.	6 AMP OUTLET WITH ONE SWITCH (2 SETS)
3.	5x6 AMP OUTLET WITH ONE SWITCH FOR TV
4.	16A POWER SOCKET WITH 16A SWITCH FOR PRINTER
5.	16A POWER SOCKET WITH 16A SWITCH
6.	16A POWER SOCKET WITH 16A SWITCH FOR AIR PURIFIER
7.	16A POWER SOCKET WITH 16A SWITCH ROOM HEATER
8.	6A POWER SOCKET FOR GEYSER
9.	1x16A RAW POWER POINT WITH 1x16A SWITCH FOR HAND DRYER
10.	2 NO. 5AMP UNIVERSAL RAW OUTLET 2 NO. 5AMP UNIVERSAL UPS OUTLET 1 USB POWER SOURCE
11.	2 NO. 13AMP UNIVERSAL OUTLET CONTROLLED BY 1 NO. 16AMP SWITCH (UPS)
12.	2 NO. 13AMP UNIVERSAL OUTLET CONTROLLED BY 1 NO. 16AMP SWITCH (RAW POWER)
13.	5 NO. 13AMP UNIVERSAL OUTLET CONTROLLED BY 1 NO. 16AMP SWITCH (RAW POWER)
14.	1x6AMP RAW POWER SOCKET
15.	1x6AMP UPS POWER SOCKET
16.	1x16AMP RAW POWER SOCKET FOR RO
17.	1x16AMP RAW POWER SOCKET FOR REFRIGERATOR

LEGEND:-		
S.NO.	SYMBOL	DESCRIPTION
1.		ONE DATA OUTLET
2.		TWO DATA OUTLET
3.		THREE DATA OUTLET
4.		TWO DATA & TWO VOICE OUTLET
5.		TWO DATA & ONE VOICE OUTLET
6.		ONE DATA & ONE VOICE OUTLET
7.		ONE VOICE OUTLET
8.		DATA OUTLET FOR LCD (CAT-6 CABLE)



TENDER DRAWING

CLIENT:
SOLAR ENERGY CORPORATION OF INDIA (SECI)

PROJECT:
ARCHITECTURAL AND ENGINEERING CONSULTANCY SERVICES FOR INTERIOR WORKS AT TOWER-F 2nd & 3rd FLOOR ,NAUROJI NAGAR, NBCC DELHI

ARCHITECT:
ATKV CONSULTANTS PVT. LTD.
E-107 (LOWER GROUND FLOOR) G.K.-II
NEW DELHI-110048
PH.NO. 40536580,29214906 TEL. FAX: 29214906

		MCK MEP Consultants B-1, 78, Alakhnesh Marg, DLF Phase 2, Sector 25, Gurugram, Haryana 122002 Email-mck_consultingengineers@gmail.com mckneprojects@gmail.com	
STAGE		DESIGN DEVELOPMENT	
DRAWING TITLE		THIRD FLOOR PLAN POWER AND DATA LAYOUT	
Designed	A.D.	Checked	Approved P.K.
Scale	Date	16.02.2025	Rev. No. R-0
Drawing No.	MCK-SECI-EL-TF-01		ORIENTATION:

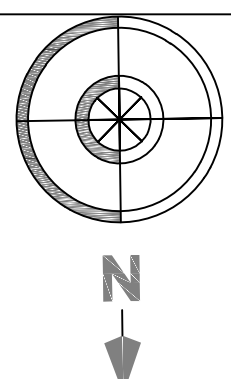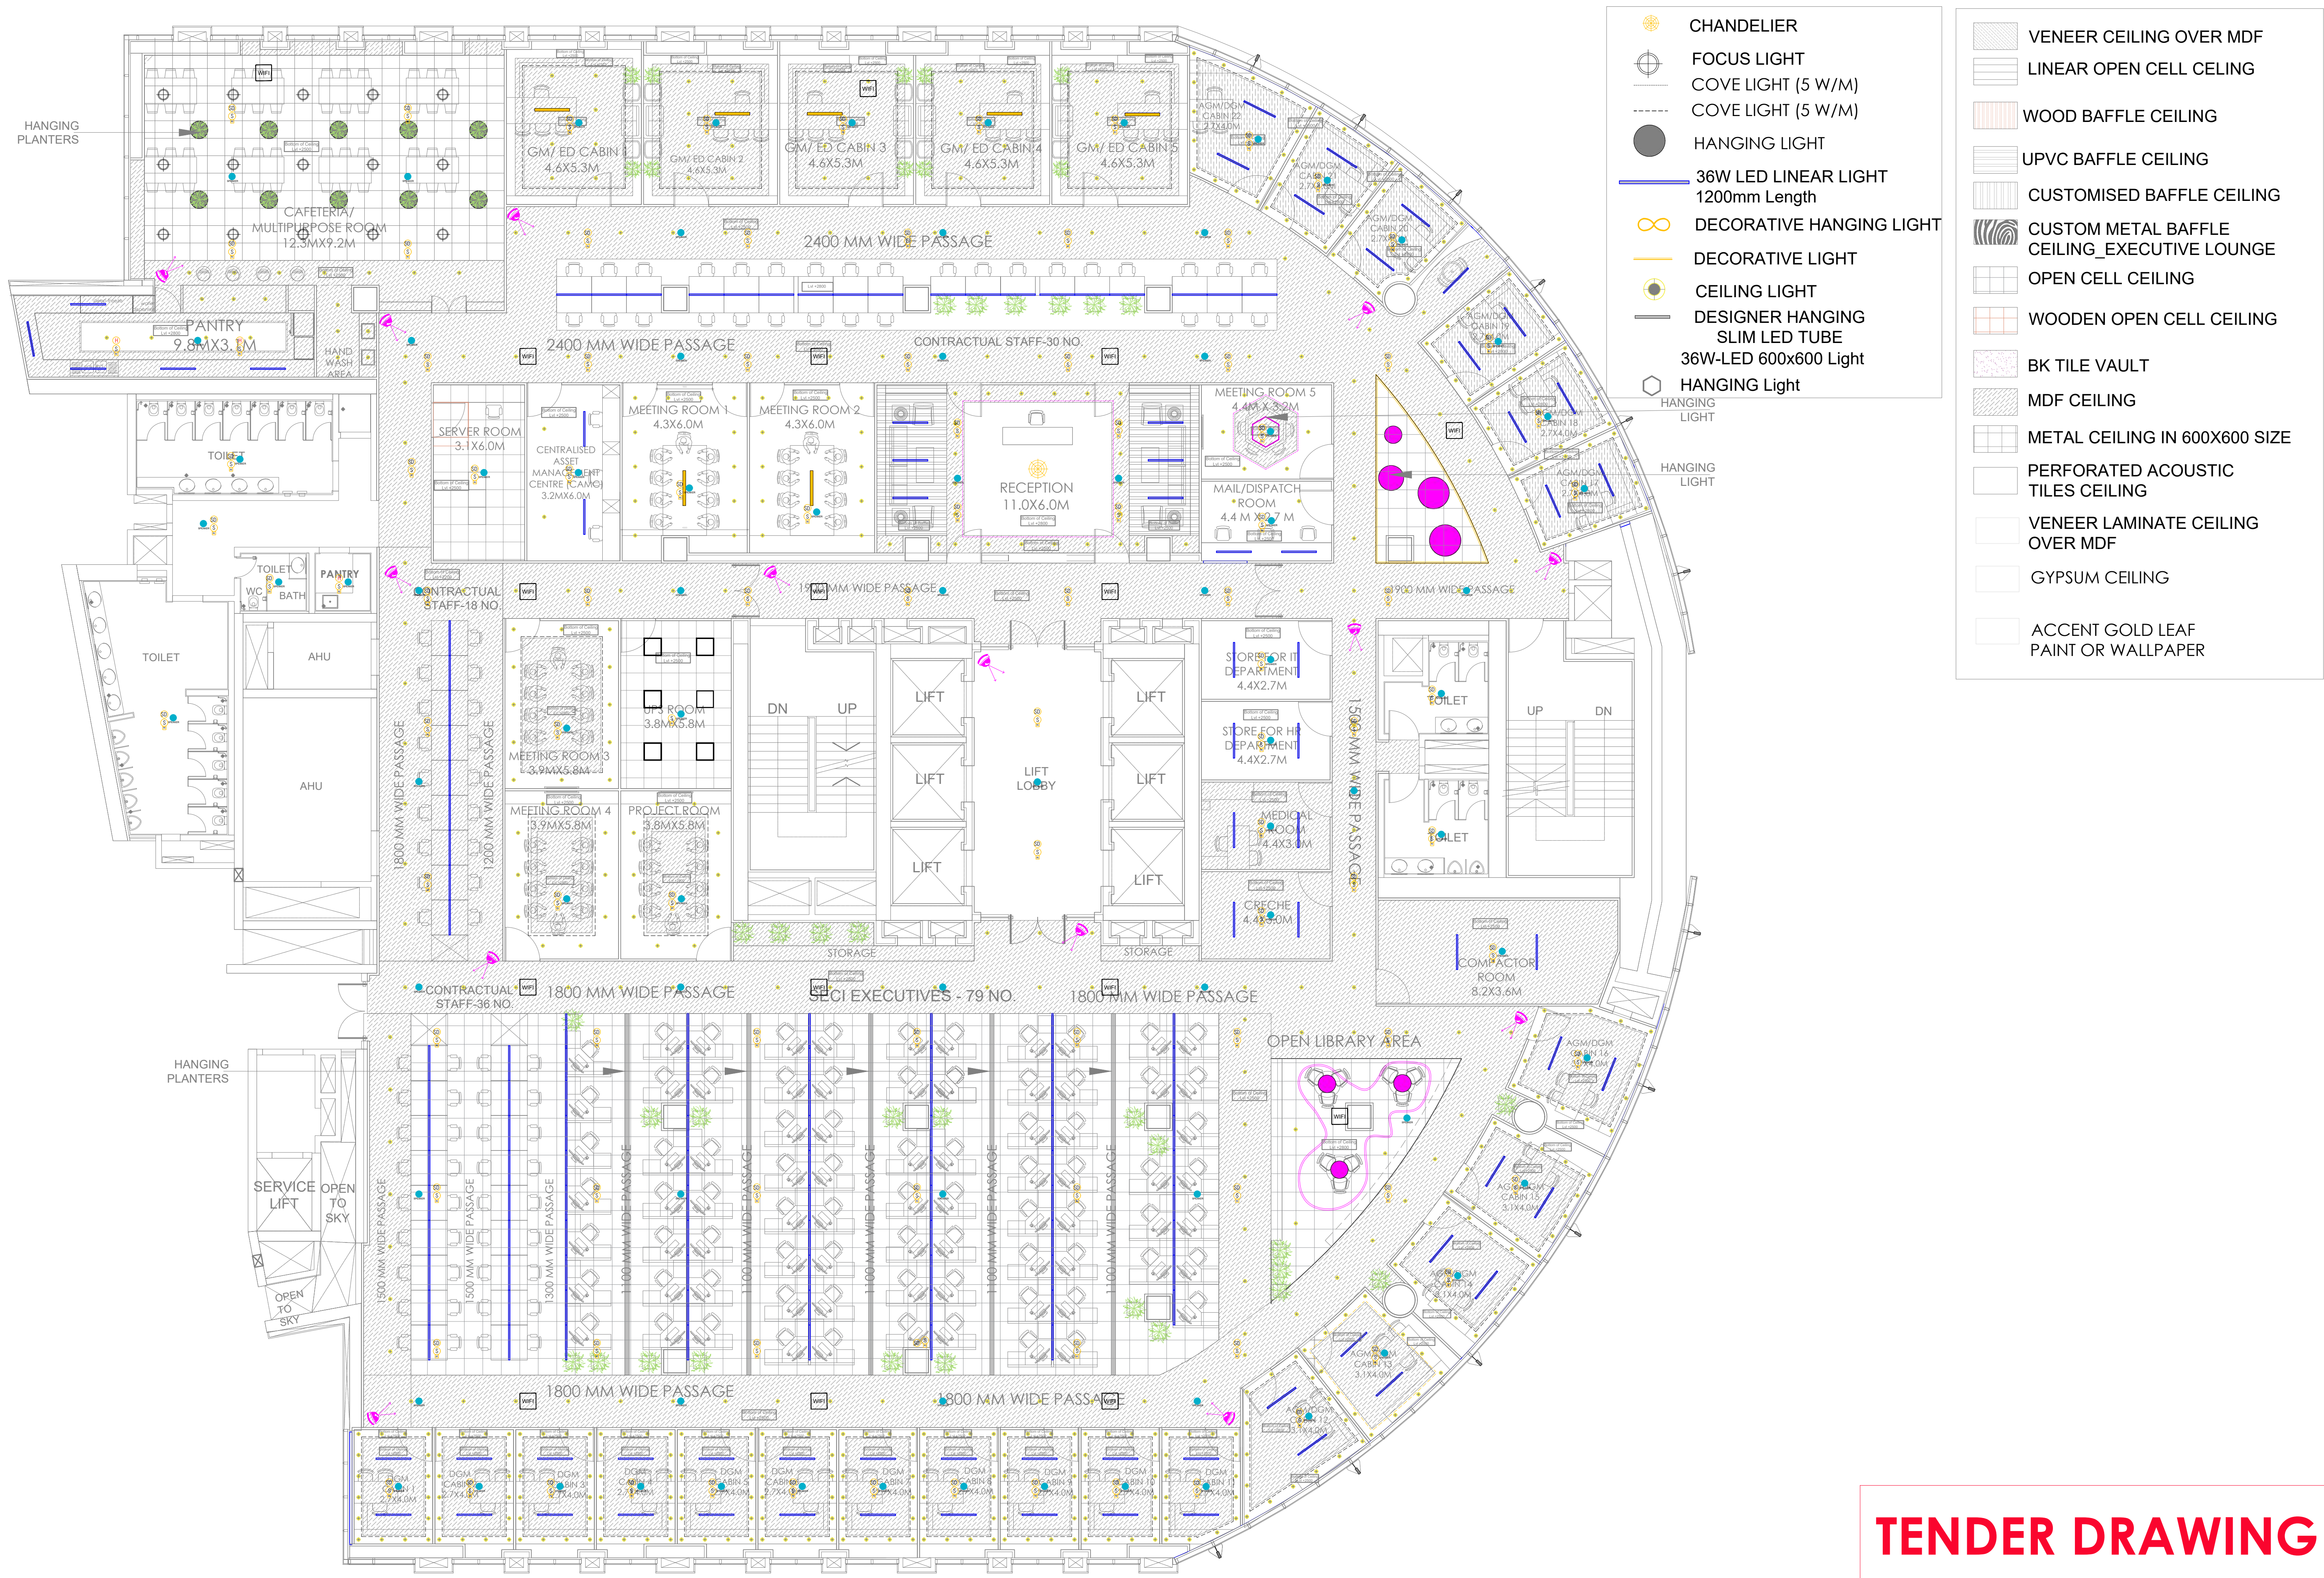

CLIENT:

SOLAR ENERGY CORPORATION OF INDIA (SECI)

PROJECT:

ARCHITECTURAL AND ENGINEERING CONSULTANCY
SERVICES FOR INTERIOR WORKS AT TOWER-F
2nd & 3rd FLOOR ,NAUROJI NAGAR, NBCC DELHI

ARCHITECT:

ATKV CONSULTANTS PVT. LTD.
E-107 (LOWER GROUND FLOOR) G.K.-II
NEW DELHI-110048
PH.NO. 40536580,29214906 TEL. FAX: 29214906

DRAWING TITLE:

SECOND FLOOR
FALSE CEILING LAYOUT

DRAWN BY : AKANKSHA

DATE :


29-01-2025

DRAWING NO: SECI-INT-SF(01)

SCALE : SHEET

NTS

A1

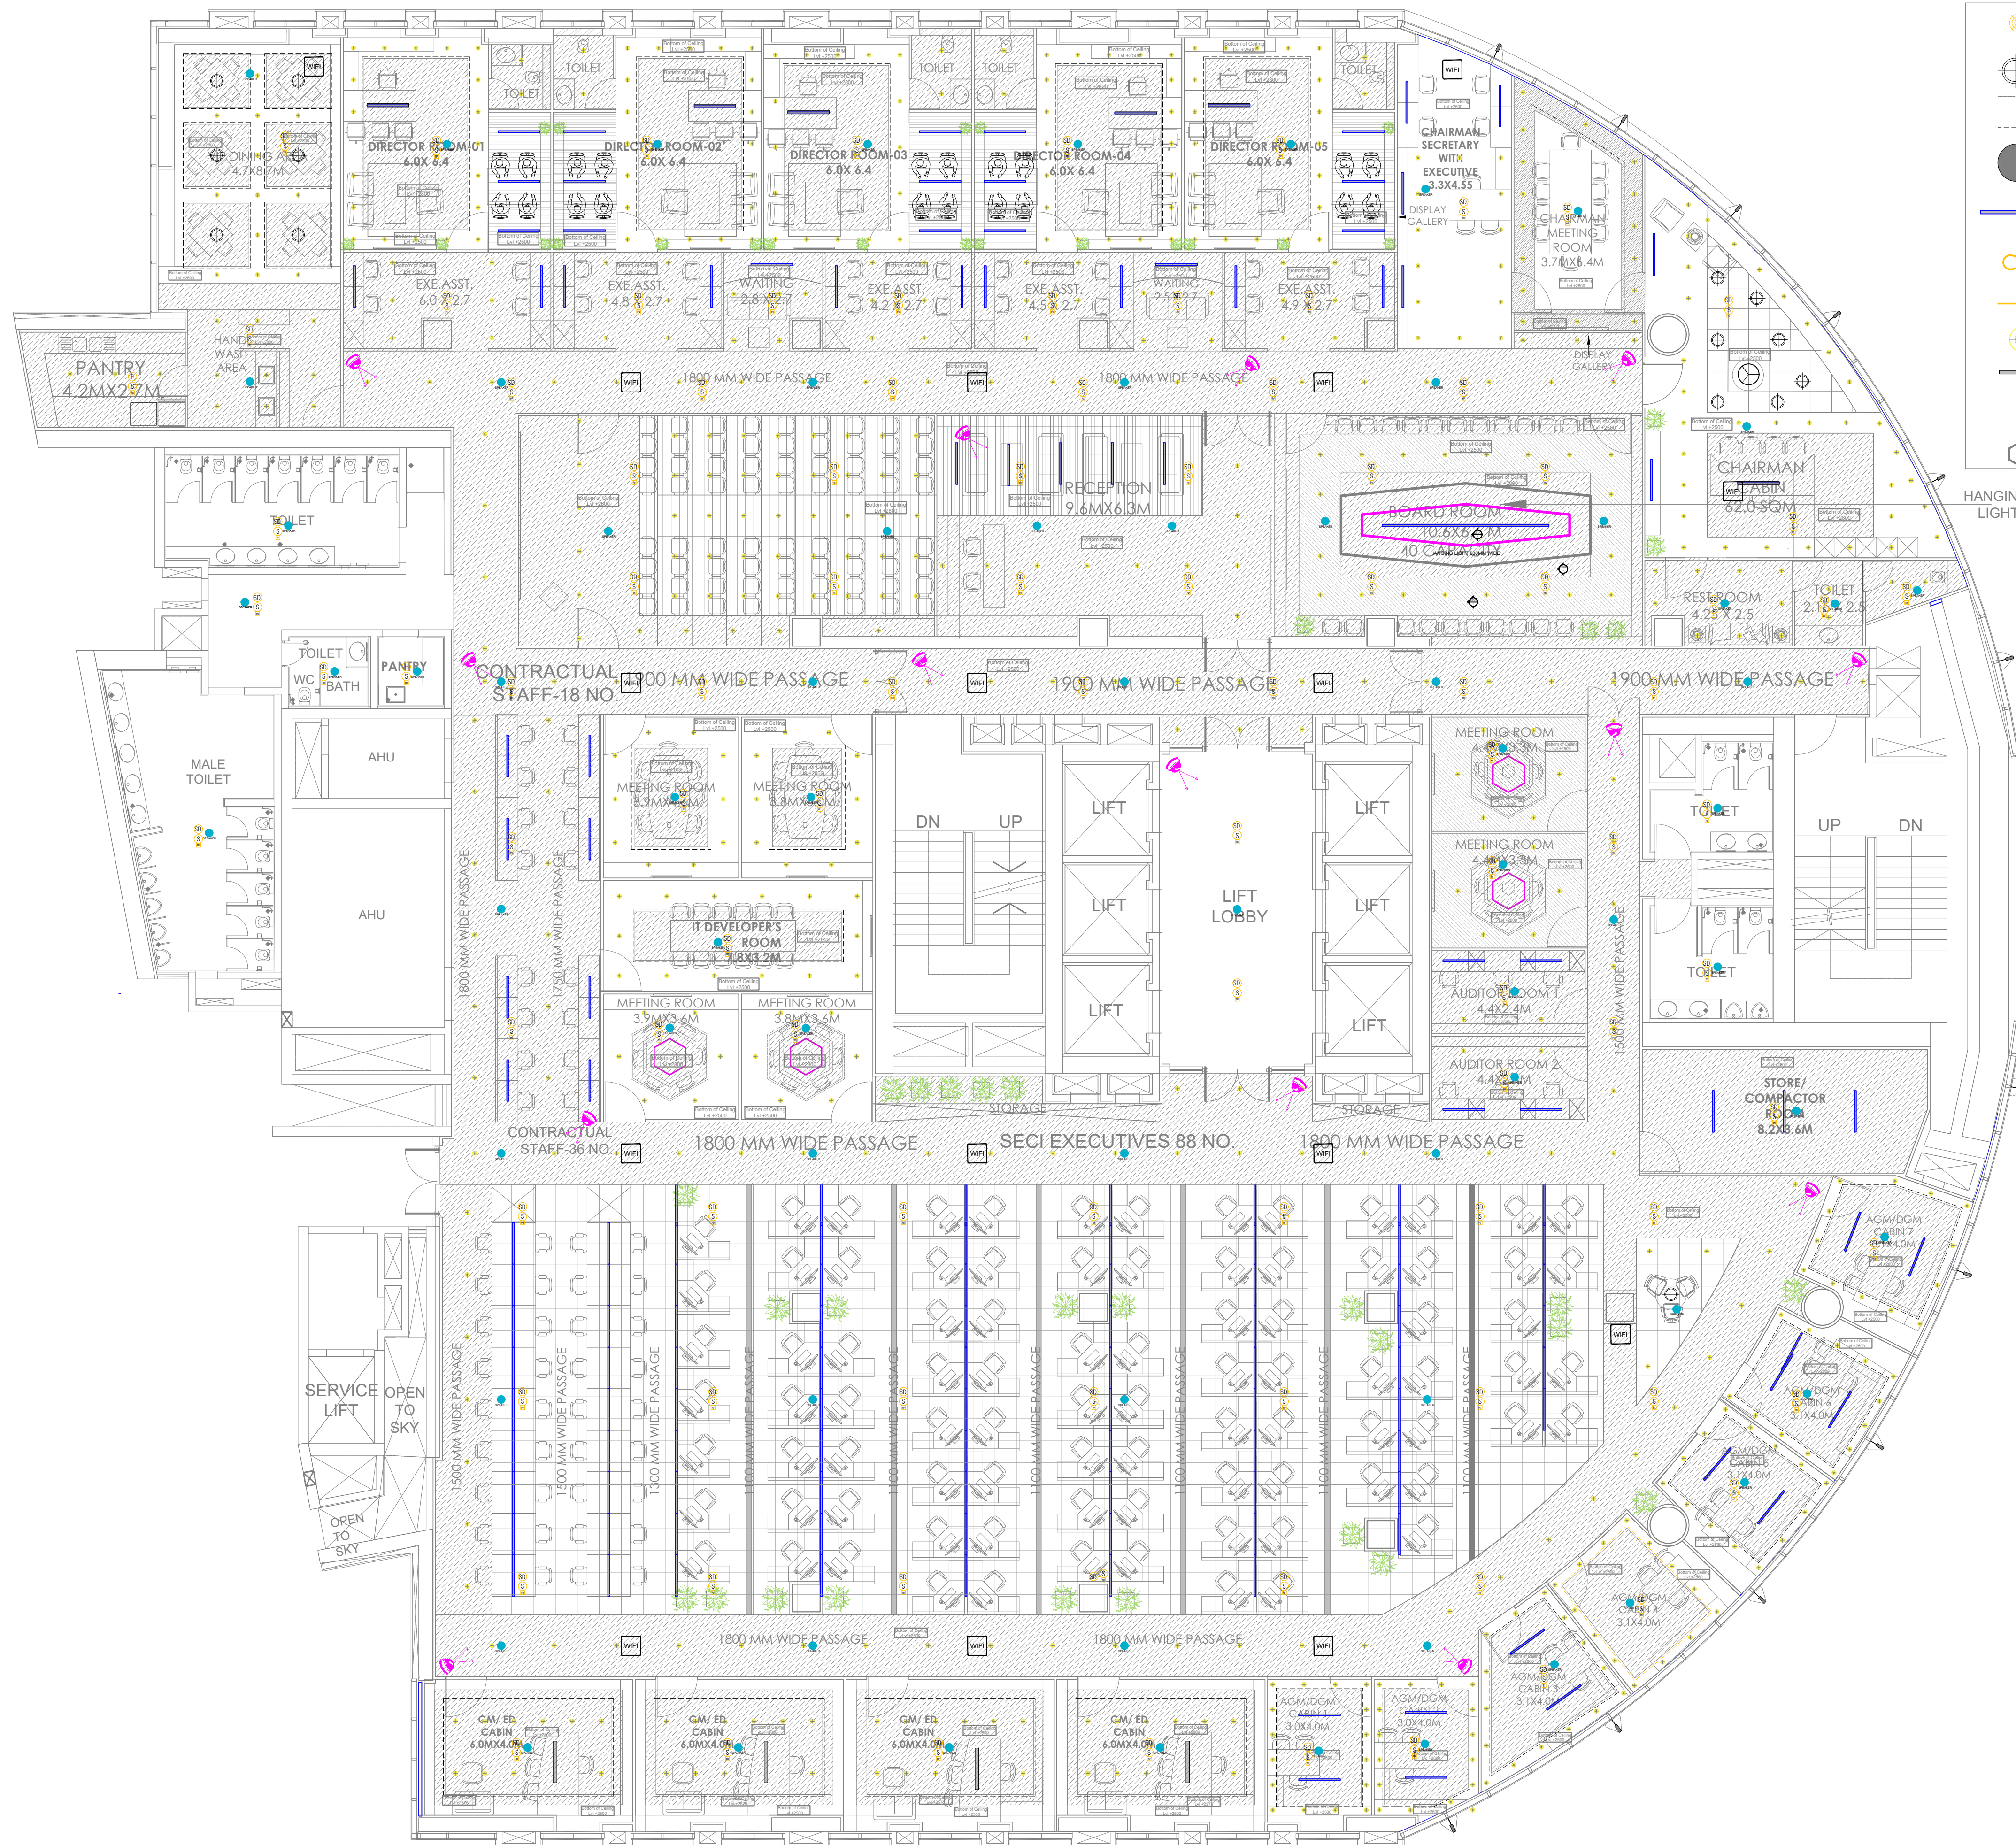

- CHANDELIER

FOCUS LIGHT

COVE LIGHT (5 W/M)

COVE LIGHT (5 W/M)

HANGING LIGHT

36W LED LINEAR LIGHT
1200mm Length

DECORATIVE HANGING LIGHT

DECORATIVE LIGHT

CEILING LIGHT

DESIGNER HANGING
SLIM LED TUBE
36W-LED 600x600 Light

HANGING Light
- VENEER CEILING OVER MDF

LINEAR OPEN CELL CEILING

ALUMINIUM/UPVC WOOD FINISH
LOUVERS

UPVC BAFFLE CEILING

CUSTOMISED BAFFLE CEILING

CUSTOM METAL BAFFLE
CEILING_EXECUTIVE LOUNGE

OPEN CELL CEILING

WOODEN OPEN CELL CEILING

BK TILE VAULT

MDF CEILING

METAL CEILING IN 600X600 SIZE


PERFORATED ACOUSTIC
TILES CEILING

VENEER LAMINATE CEILING
OVER MDF

GYPSUM CEILING

ACCENT GOLD LEAF
PAINT OR WALLPAPER

TENDER DRAWING

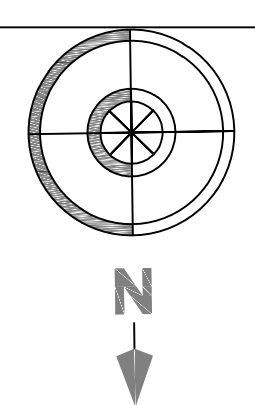

CLIENT:	PROJECT:	ARCHITECT:	DRAWING TITLE:	DATE :	SCALE :	SHEET
SOLAR ENERGY CORPORATION OF INDIA (SECI)	ARCHITECTURAL AND ENGINEERING CONSULTANCY SERVICES FOR INTERIOR WORKS AT TOWER-F 2nd & 3rd FLOOR ,NAUROJI NAGAR, NBCC DELHI	ATKV CONSULTANTS PVT. LTD. E-107 (LOWER GROUND FLOOR) G.K.-II NEW DELHI-110048 PH.NO. 40536580,29214906 TEL. FAX: 29214906	THIRD FLOOR FALSE CEILING LAYOUT	29-01-2025	NTS	A1
DRAWN BY : AKANKSHA				DRAWING NO: SECI-INT-TF(01)		